LUMINAIRE LO	LUMINAIRE LOCATION SUMMARY						
LUM NO.	LABEL	MTG. HT.					
1	A	23					
2	A	23					
3	A1	23					
4	A2	23					
5	A2	23					
6	В	23					
7	В	23					
8	В	23					
9	D	9					
10	D	9					
11	D	9					
12	D	9					
13	D	9					
14	D	9					
15	D	9					
16	D	9					
17	D	9					
18	D	9					

FOOTCANDLE LEVELS CALCULATED AT GRADE USING INITIAL LUMEN VALUES						
LABEL	AVG	MAX	MIN	AVG/MIN	MAX/MIN	
PAVED AREA	3.82	12.7	0.8	4.78	15.88	
UNDEFINED AREA	1.03	19.5	0.0	N.A.	N.A.	

LUMINAIRE SCHEDULE										
SYMBOL	QTY	LABEL	ARRANGEMENT	LUMENS	LLF	BUG RATING	WATTS/LUMINAIRE	TOTAL WATTS	MANUFACTURE	CATALOG LOGIC
	2	Α	SINGLE	13374	1.000	B3-U0-G2	85	170	Cree Inc	OSQ-ML-B-DA + OSQM-B-16L-40K7-3M-UL-NM-XX-Q9
"	1	A1	2 @ 90 DEG	13374	1.000	B3-U0-G2	85	170	Cree Inc	OSQ-ML-B-DA + OSQM-B-16L-40K7-3M-UL-NM-XX-Q9
	2	A2	BACK-BACK	13374	1.000	B3-U0-G2	85	340	Cree Inc	OSQ-ML-B-DA + OSQM-B-16L-40K7-3M-UL-NM-XX-Q9
-	3	В	SINGLE	12699	1.000	B2-U0-G2	104	312	Cree Inc	OSQ-ML-B-DA + OSQM-B-16L-40K7-3M-UL-NM-XX-Q9 + OSQ-BLSMF
>	10	D	SINGLE	6094	1.000	B1-U0-G2	46.95	469.5	Cree Inc	XSPW-B-WM-3ME-6L-40K-UL-XX

 $\sqrt[7]{3.5}$ $\sqrt[3]{3.5}$ $\sqrt[4]{2.3}$ $\sqrt[4]{1.5}$ $\sqrt[6]{0.8}$ $\sqrt[6]{0.4}$ $\sqrt[6]{0.2}$ $\sqrt[6]{0.1}$

 $\vec{3}.5$ $\vec{3}.6$ $\vec{5}.0$ $\vec{4}.9$ $\vec{3}.8$ $\vec{3}.5$ $\vec{2}.2$ $\vec{1}.2$ $\vec{0}.7$ $\vec{0}.4$ $\vec{0}.2$ $\vec{0}.1$

 $1 \quad 1.5 \quad 8.0 \quad 4.5 \quad 4.6 \quad 3.9 \quad 2.4 \quad 1.5 \quad 0.6 \quad 0.3 \quad 0.2 \quad 0.1 \quad 0.1 \quad 0.1$

₩ <u></u>	REDLEONARD ASSOCIATES
1340 Ker	mper Meadow Dr, Forest Park, OH 45240

513-574-9500 | redleonard.com

 REV.
 BY
 DATE

 R1
 TAS
 4/20/22

 .
 .
 .

DESCRIPTION
ADDED 2 TYPE "D" FIXTURES
.

0.0 0.0 0.1 0.2 0.8 1/9 1.0 1.6 1.4

0.0 0.1 0.1 0.2 1.3 1.7 0.4 1.4 1.2 1.4

 $\dot{0}.0$ $\dot{0}.0$ $\dot{0}.1$ $\dot{0}.2$

ō.o ō.o ō.h

0.0 0.1 0.1 0.3 1.7

0.8 1.7 2.9 3.0 3.5 8.5

0.0 0.0

0.0 0.1 0.1 0.2 0.3 0.8 0.8 0.7 0.3 0.8

0.0 0.0 0.0 0.0 0.0 0.1 0.0 0.0 0.1 0.0

0.4 0.8 0.8 0.0

 $\sqrt[4]{.}$ 1 $\sqrt[5]{.}$ 2 $\sqrt[5]{.}$ 4 $\sqrt[5]{.}$ 6 $\sqrt[5]{.}$ 8 $\sqrt[5]{.}$ 7 $\sqrt[5]{.}$ 5 $\sqrt[5]{.}$ 7 $\sqrt[5]{.}$ 8 $\sqrt[5]{.}$ 9 $\sqrt[5]{.}$ 9

0.0 0.1 0.1 0.2 0.3 0.5 0.8 0.8 0.8 0.7 0.4 0.3 0.4 0.6 0.7 0.5 0.4 0.4 0.5 0.6 0.5 0.5 0.8 0.8 0.9 0.5 0.5 0.2 0.1 0.1 0.1 0.1 0.1 0.0 0.0 0.0 0.0 0.0 0.0

 $\dot{0}$.0 $\dot{0}$.0 $\dot{0}$.1 $\dot{0}$.1 $\dot{0}$.2 $\dot{0}$.3 $\dot{0}$.4 $\dot{0}$.3 $\dot{0}$.2 $\dot{0}$.1 $\dot{0}$.0 \dot

 $\overset{1}{0}.0$ $\overset{1}{0}.0$ $\overset{1}{0}.0$ $\overset{1}{0}.0$ $\overset{1}{0}.0$ $\overset{1}{0}.1$ $\overset{1}{0}.1$ $\overset{1}{0}.1$ $\overset{1}{0}.1$ $\overset{1}{0}.0$ $\overset{1}$

NEW HALO CAR WASH

[†]3.0 [†]3.9 [†]

1.8 3.7 5.0 5.6 7.2 6.7 6.7 6.9 3.5 2.6 2.5 1.3 0.6 0.3 0.2 0.1 0.1


1.7 1.3 1.3 1.8 1.5 1.5 1.2 1.1

 $\begin{bmatrix} 0.0 & 0.0 & 0.1 & 0.2 \end{bmatrix} \begin{bmatrix} 0.3 & 0.5 & 0.7 & 0.9 & 1.0 & 1.2 & 1.3 & 1.2 & 1.0 & 0.9 & 0.9 & 0.8 & 0.8 & 0.8 & 0.8 & 0.8 & 0.8 & 0.8 & 0.8 & 0.5 & 0.5 & 0.6 & 1.0 & 1.8 & 1.6 & 1.4 & 1.6 & 1.2 & 1.2 & 1.7 & 0.4 & 0.2 & 0.7 & 0.4 & 0.2 & 0.7 & 0.8 &$

ANY SITE PLAN(S), FLOOR PLAN(S), RENDERING(S), LIGHTING LAYOUT(S) AND PHOTOMETRIC PLAN(S) INCLUDING BUT NOT LIMITED TO ANY PROJECT(S) CREATED/PRODUCED BY RED LEONARD ASSOCIATES INC., ARE ONLY INTENDED FOR ILLUSTRATION AND QUOTING PURPOSES ONLY. RED LEONARD ASSOCIATES HAS THE RIGHT TO USE THIRD PARTY LASERS, SCANNERS, AND CAMERAS BUT ACTUAL PROJECT CONDITIONS, DIMENSIONS, AND ACCURACY OF MEASUREMENTS MAY DIFFER FROM THESE OR ANY PARAMETERS. RED LEONARD ASSOCIATES INC. ASSUMES NO LIABILITY FOR WHAT IS CREATED/PRODUCED IN THESE RECREATIONS. THIS INCLUDES BUT IS NOT LIMITED TO THE USE OF, INSTALLATION OF AND/OR INTEGRITY OF EXISTING BUILDING(S), SURROUNDING AREA FOR PRODUCT(S) SUCH AS EXISTING POLE(S), ANCHOR BOLT(S), BASE(S), ARCHITECTURAL AND SIGNAGE STRUCTURE(S), LANDSCAPING PLAN(S), LIGHTING PLAN(S), FIXTURE SELECTION(S) AND PLACEMENT, MATERIAL(S), COLOR ACCURACY, TEXTURE(S), AND ANYTHING ATTRIBUTED TO PHOTO REALISM THAT IS CREATED. FURTHERMORE, RED LEONARD ASSOCIATES INC., DOES NOT ASSUME LIABILITY WHATSOEVER FOR ANY PURCHASES MADE BY CLIENT BEFORE, DURING, OR AT THE CONCLUSION OF THE PUBLISHED WORK. THE CUSTOMER, ITS RELATIVE AFFILIATES, AS WELL AS ANY OTHER PERSON(S) IN VIEWING OF THIS PRODUCT IS RESPONSIBLE FOR VERIFYING COMPLIANCE WITH ANY BUT NOT LIMITED TO ALL CODES, PERMITS, RESTRICTIONS, INSTRUCTIONS, PURCHASES, AND INSTALLATIONS OF OBJECTS VIEWED WITHIN THIS DOCUMENT(S) OR PROJECT(S). SYMBOLS ARE NOT DRAWN TO SCALE. SIZE IS FOR CLARITY PURPOSES ONLY. SIZES AND DIMENSIONS ARE APPROXIMATE, ACTUAL MEASUREMENTS MAY VARY. DRAWINGS ARE NOT INTENDED FOR ENGINEERING OR CONSTRUCTION USE. THIS DOCUMENT, ANY RED LEONARD DRAWING(S), OR PROJECT(S) IS NOT TO BE USED AND/OR INTENDED FOR ENGINEERING OR CONSTRUCTION PURPOSES, BUT FOR ILLUSTRATIVE PURPOSES ONLY. ANY LOCATIONS OF EMERGENCY LIGHTING SHOWN WERE PROVIDED BY OTHERS. RED LEONARD ASSOCIATES IS NOT RESPONSIBLE FOR INSUFFICIENT LIGHTING DURING AN EMERGENCY EVENT. ANY USE OF THIS DOCUMENTATION AND/OR OTHER ARTICLES PRODUCED BY RED LEONARD WITHOUT WRITTEN AUTHORI

SCALE: LAYOUT BY: 1" = 20' TAS DWG SIZE: DATE: D 4/19/22

HALO CARWASH BARRHAVEN, ON DRAWING NUMBER: RL-7978-S1-R1

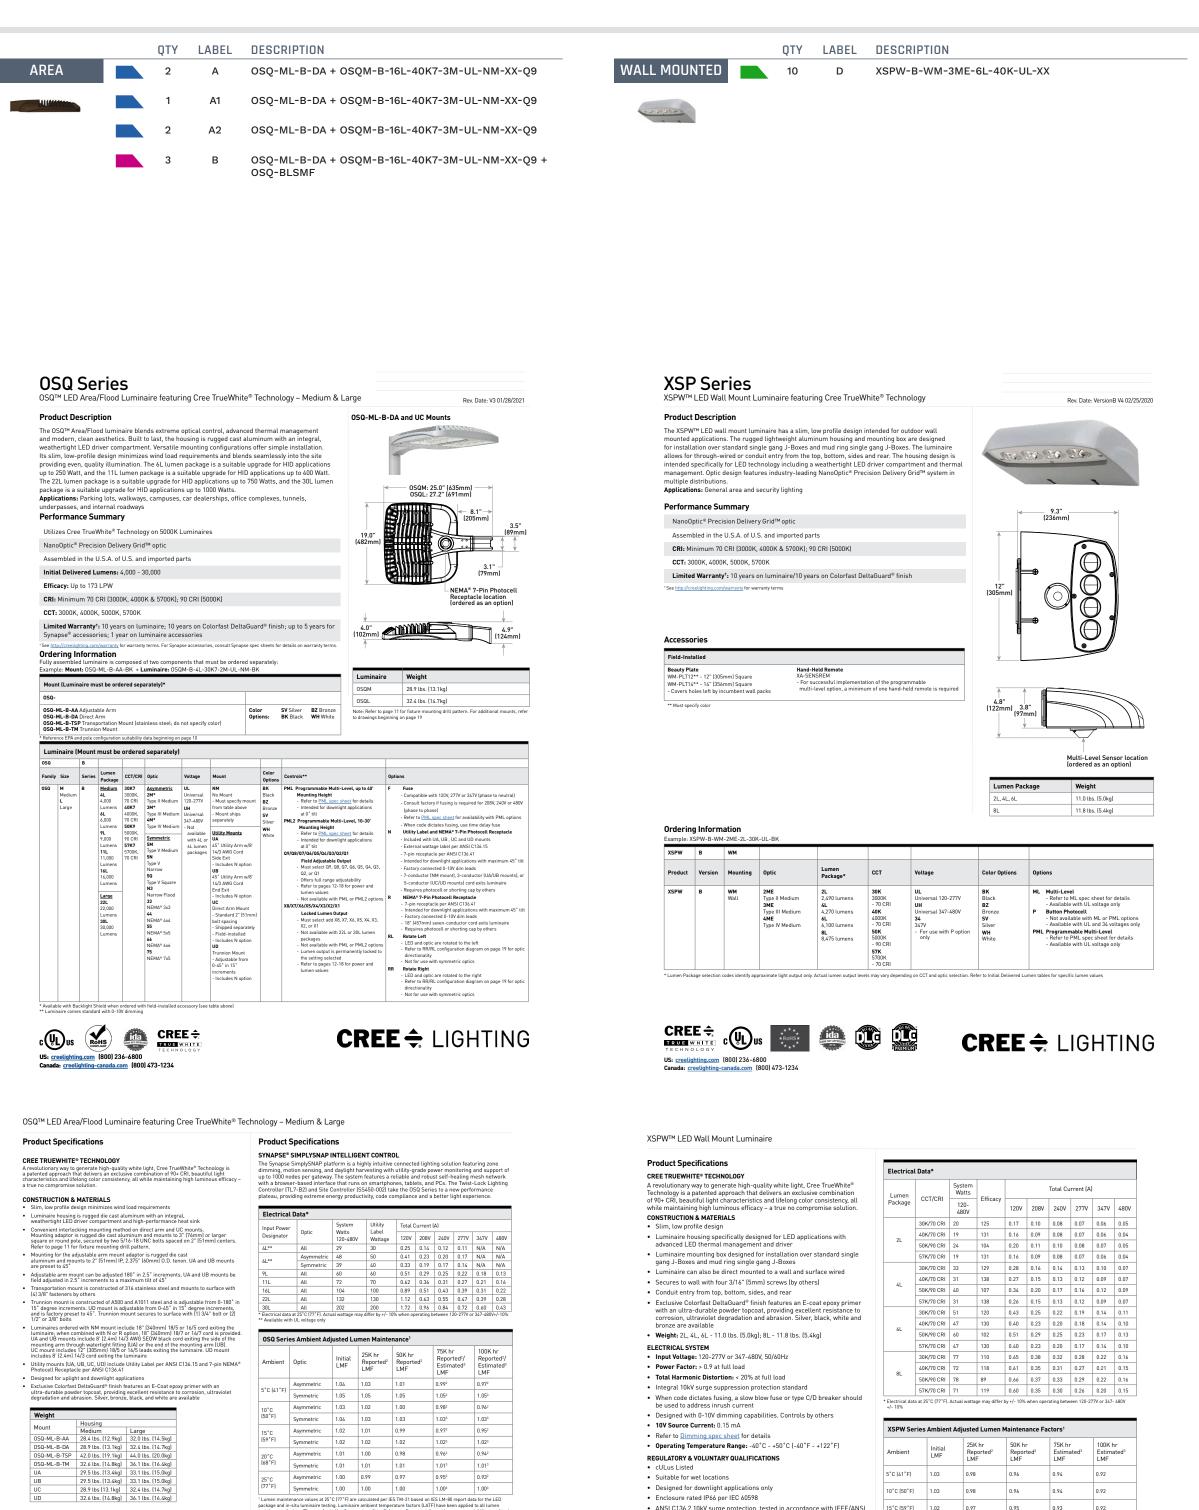

SimplySNAP On-Site Controller SS450-002 - Verizon® LTE-enabled - Designed for indoor applications - Refer to SS450-002 spec sheet for d - Refer to <u>5545-002</u> spec sheet for details Building Management System (BMS) Gateway BMS-GW-002. Required for BACnet integration - Refer to <u>BMS-GW-002</u> spec sheet for details Outdoor Antennas (Optional, for increased range, 8dB gain) KIT-ANT 1202 annenna, 20° cable and bracket KIT-ANT303 - Antenna 30° cable and bracket - KIT-ANT3040 - Antenna 30° cable and bracket - KIT-ANT3040 - Antenna 30° cable and bracket KIT-ANT360

- Kit includes antenna, 30° cable and bracket KIT-ANT600

- Kit includes antenna, 50° cable and bracket Refer to <u>Outdoor antenna spec sheet</u> for details

CREE : LIGHTING

US: creelighting.com (800) 236-6800 Canada: creelighting-canada.com (800) 473-1234

 Suitable for wet locations Designed for downlight applications only Enclosure rated IP66 per IEC 60598

ANSI C136.2 10kV surge protection, tested in accordance with IEEE/ANSI

Luminaire and finish endurance tested to withstand 5,000 hours of elevated ambient salt fog conditions as defined in ASTM Standard B 117

Meets Buy American requirements within ARRA

 RoHS compliant. Consult factory for additional details Dark Sky Friendly, IDA Approved when ordered with 30K CCT. Please refer to https://www.darksky.org/our-work/lighting/lighting-for-industry/fsa/fsa-products/ for most current information DLC and DLC Premium qualified versions available. Please refer to https://www.designlights.org/search/ for most current information

CA RESIDENTS WARNING: Cancer and Reproductive Harm –

www.p65warnings.ca.gov

Meets FCC Part 15, Subpart B, Class A limits for conducted and radiated | 20°C [68°F] | 1.01 | 0.96

25°C (77°F) 1.00 0.96

17

30°C (86°F) 0.99 0.95 0.93 0.91 0.89

35°C (95°F) 0.98 0.94 0.92 0.90 0.88

40°C (104°F) 0.97 0.93 0.91 0.89 0.87

Lumen maintenance values at 25°C (77°F) are calculated per IES TM-21 has advantaged and in-situ huminative scales.

nuons.

ccordance with IES TM-21, Reported values represent interpolated values based on time durations that are
6x the tested duration in the IES LM-80 report for the LED.

CREE : LIGHTING



US: creelighting.com (800) 236-6800 Canada: creelighting-canada.com (800) 473-1234

ELECTRICAL SYSTEM

Input Voltage: 120-277V or 347-480V, 50/60Hz, Class 1 drivers
Power Factor: 9.0, a fluit load

Total Harmonic Distortion: < 20% at full load


Designed with 0-10V dimming capabilities. Controls by others

REGULATORY & VOLUNTARY QUALIFICATIONS

When code dictates fusing, a slow blow fuse or type C/D breaker should be udress inrush current


Luminaire and finish endurance tested to withstand 5,000 hours of elevated ambient salt fog conditions as defined in ASTM Standard B 117

ANY SITE PLAN(S), FLOOR PLAN(S), RENDERING(S), LIGHTING LAYOUT(S) AND PHOTOMETRIC PLAN(S) INCLUDING BUT NOT LIMITED TO ANY PROJECT(S) CREATED/PRODUCED BY RED LEONARD ASSOCIATES INC., ARE ONLY INTENDED FOR ILLUSTRATION AND QUOTING PURPOSES ONLY. RED LEONARD ASSOCIATES HAS THE RIGHT TO USE THIRD PARTY LASERS, SCANNERS, AND CAMERAS BUT ACTUAL PROJECT CONDITIONS, DIMENSIONS, AND ACCURACY OF MEASUREMENTS MAY DIFFER FROM THESE OR ANY PARAMETERS. RED LEONARD ASSOCIATES INC. ASSUMES NO LIABILITY FOR WHAT IS CREATED/PRODUCED IN THESE RECREATIONS. THIS INCLUDES BUT IS NOT LIMITED TO THE USE OF, INSTALLATION OF AND/OR INTEGRITY OF EXISTING BUILDING(S), SURROUNDING AREA FOR PRODUCT(S) SUCH AS EXISTING POLE(S), ANCHOR BOLT(S), BASE(S), ARCHITECTURAL AND SIGNAGE STRUCTURE(S), LANDSCAPING PLAN(S), LIGHTING PLAN(S), FIXTURE SELECTION(S) AND PLACEMENT, MATERIAL(S), COLOR ACCURACY, TEXTURE(S), AND ANYTHING ATTRIBUTED TO PHOTO REALISM THAT IS CREATED, FURTHERMORE, RED LEONARD ASSOCIATES INC., DOES NOT ASSUME LIABILITY WHATSOEVER FOR ANY PURCHASES MADE BY CLIENT BEFORE, DURING, OR AT THE CONCLUSION OF THE PUBLISHED WORK, THE CUSTOMER, ITS RELATIVE AFFILIATES, AS WELL AS ANY OTHER PERSON(S) IN VIEWING OF THIS PRODUCT IS RESPONSIBLE FOR VERIFYING COMPLIANCE WITH ANY BUT NOT LIMITED TO ALL CODES, PERMITS, RESTRICTIONS, INSTRUCTIONS, PURCHASES, AND INSTALLATIONS OF OBJECTS VIEWED WITHIN THIS DOCUMENT(S) OR PROJECT(S). SYMBOLS ARE NOT DRAWN TO SCALE. SIZE IS FOR CLARITY PURPOSES ONLY. SIZES AND DIMENSIONS ARE APPROXIMATE, ACTUAL MEASUREMENTS MAY VARY. DRAWINGS ARE NOT INTENDED FOR ENGINEERING OR CONSTRUCTION USE. THIS DOCUMENT, ANY RED LEONARD DRAWING(S), OR PROJECT(S) IS NOT TO BE USED AND/OR INTENDED FOR ENGINEERING OR CONSTRUCTION PURPOSES, BUT FOR ILLUSTRATIVE PURPOSES ONLY. ANY USE OF THIS DOCUMENTATION AND/OR OTHER ARTICLES PRODUCED BY RED LEONARD WITHOUT WRITTEN AUTHORIZATION FROM JAYME J. LEONARD IS STRICTLY PROHIBITED.

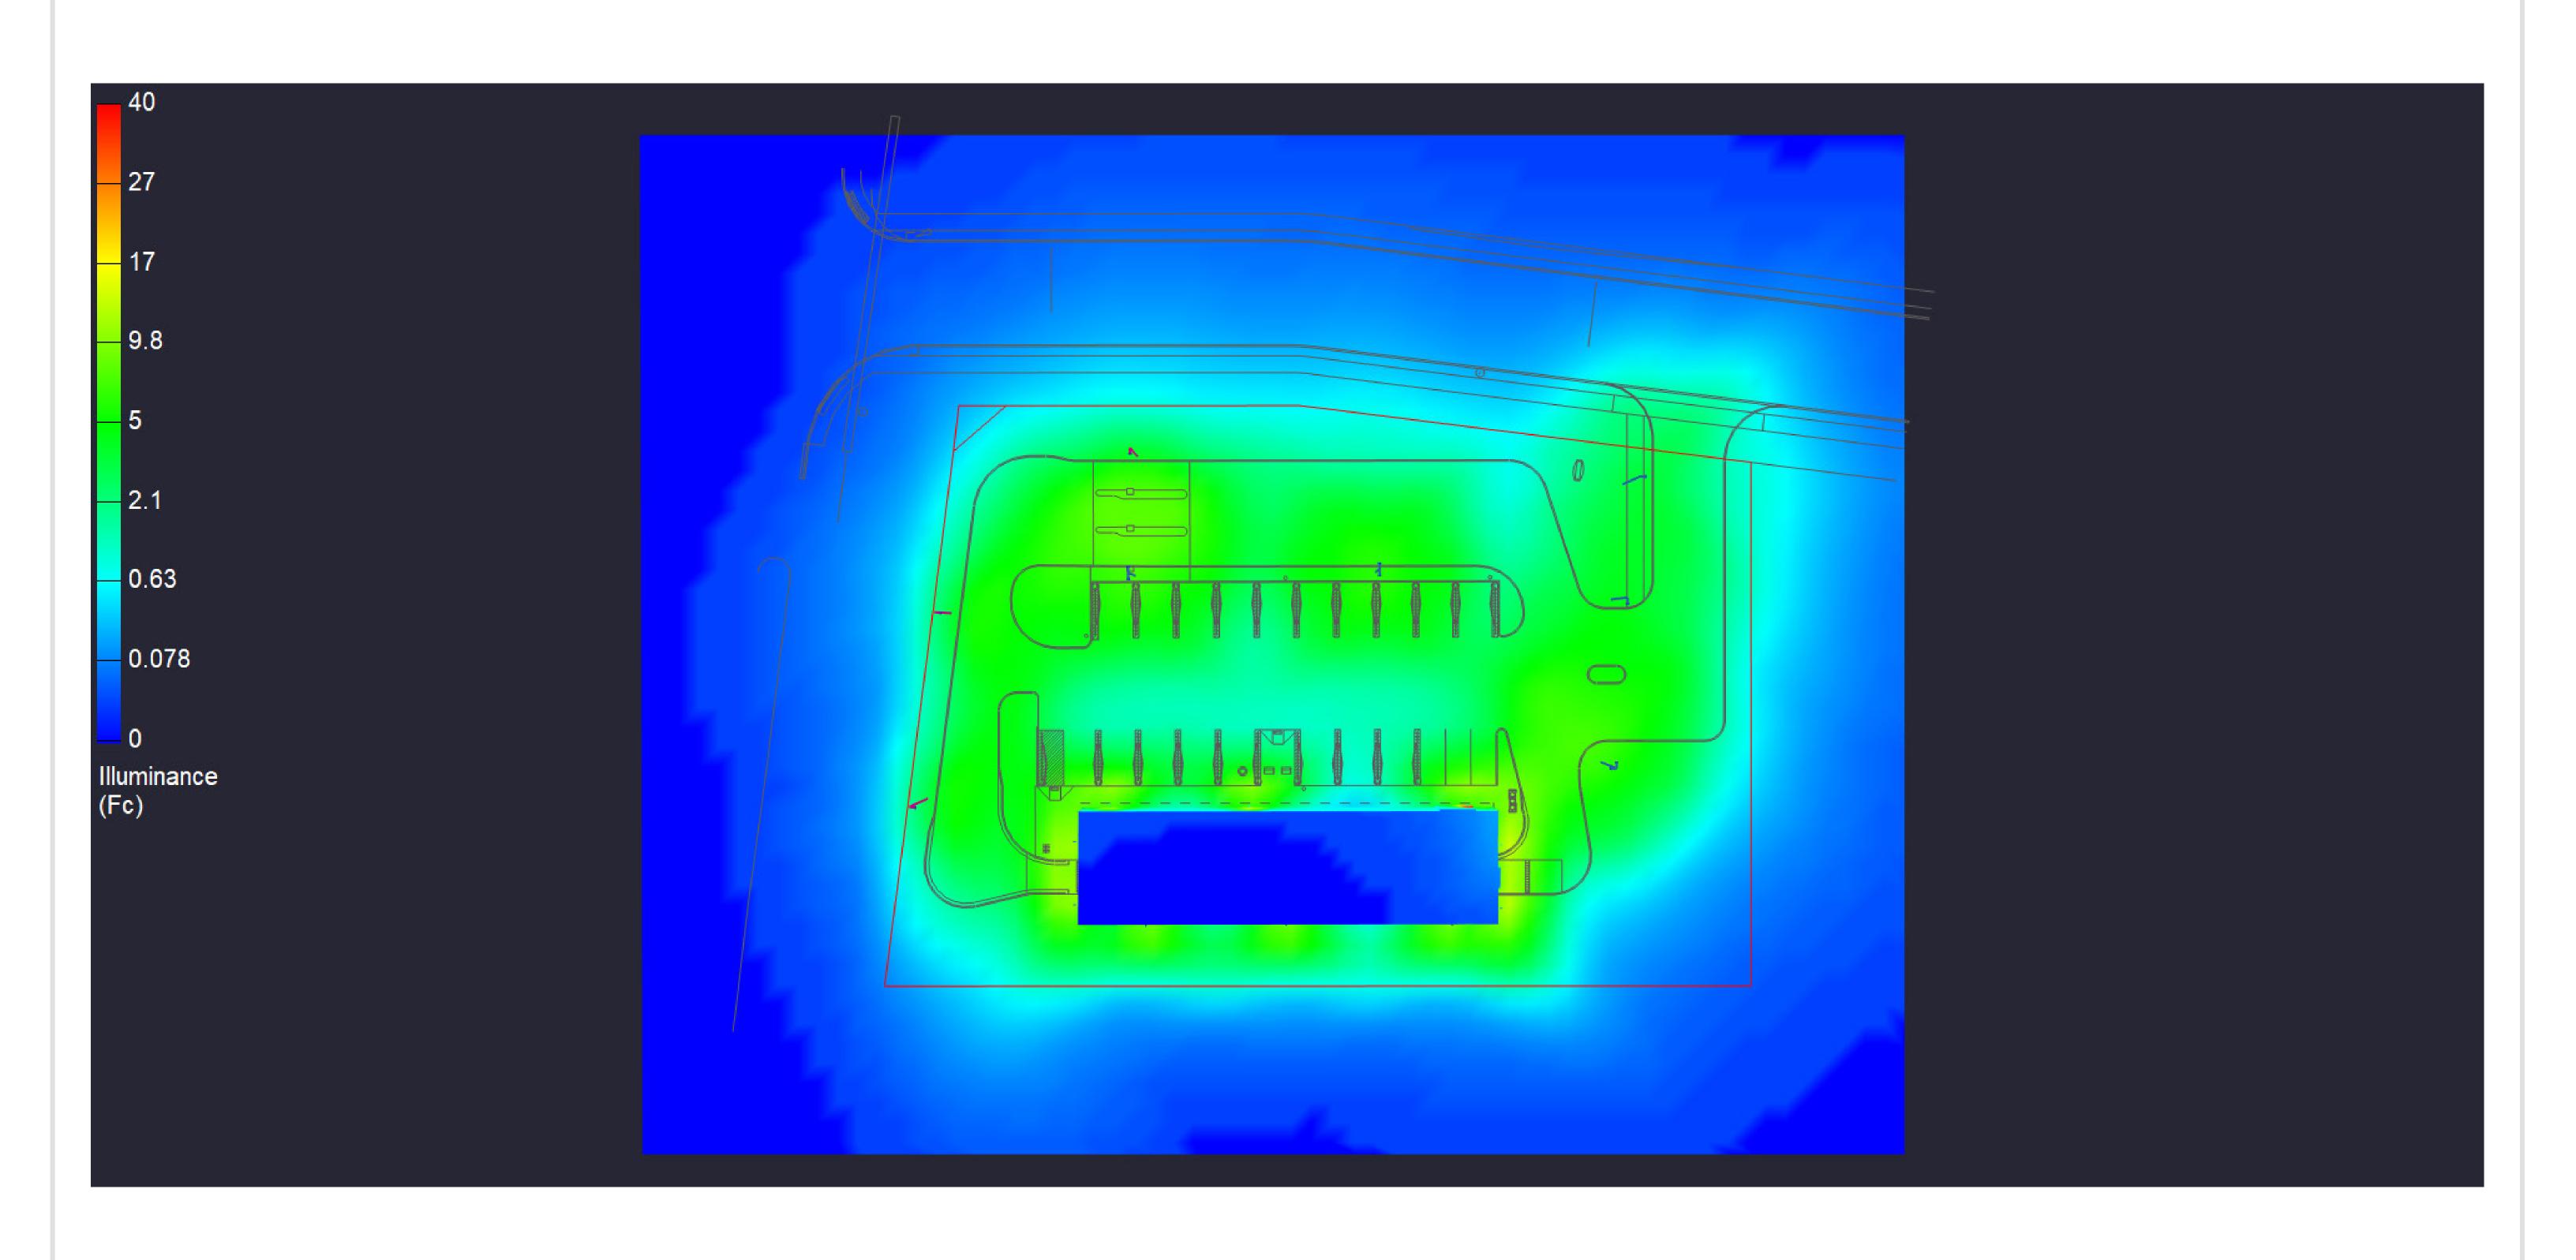




ANY SITE PLAN(S), FLOOR PLAN(S), RENDERING(S), LIGHTING LAYOUT(S) AND PHOTOMETRIC PLAN(S) INCLUDING BUT NOT LIMITED TO ANY PROJECT(S) CREATED/PRODUCED BY RED LEONARD ASSOCIATES INC., ARE ONLY INTENDED FOR ILLUSTRATION AND QUOTING PURPOSES ONLY. RED LEONARD ASSOCIATES HAS THE RIGHT TO USE THIRD PARTY LASERS, SCANNERS, AND CAMERAS BUT ACTUAL PROJECT CONDITIONS, DIMENSIONS, AND ACCURACY OF MEASUREMENTS MAY DIFFER FROM THESE OR ANY PARAMETERS. RED LEONARD ASSOCIATES INC. ASSUMES NO LIABILITY FOR WHAT IS CREATED/PRODUCED IN THESE RECREATIONS. THIS INCLUDES BUT IS NOT LIMITED TO THE USE OF, INSTALLATION OF AND/OR INTEGRITY OF EXISTING BUILDING(S), SURROUNDING AREA FOR PRODUCT(S) SUCH AS EXISTING POLE(S), ANCHOR BOLT(S), BASE(S), ARCHITECTURAL AND SIGNAGE STRUCTURE(S), LANDSCAPING PLAN(S), LIGHTING PLAN(S), FIXTURE SELECTION(S) AND PLACEMENT, MATERIAL(S), COLOR ACCURACY, TEXTURE(S), AND ANYTHING ATTRIBUTED TO PHOTO REALISM THAT IS CREATED. FURTHERMORE, RED LEONARD ASSOCIATES INC., DOES NOT ASSUME LIABILITY WHATSOEVER FOR ANY PURCHASES MADE BY CLIENT BEFORE, DURING, OR AT THE CONCLUSION OF THE PUBLISHED WORK. THE CUSTOMER, ITS RELATIVE AFFILIATES, AS WELL AS ANY OTHER PERSON(S) IN VIEWING OF THIS PRODUCT IS RESPONSIBLE FOR VERIFYING COMPLIANCE WITH ANY BUT NOT LIMITED TO ALL CODES, PERMITS, RESTRICTIONS, INSTRUCTIONS, PURCHASES, AND INSTALLATIONS OF OBJECTS VIEWED WITHIN THIS DOCUMENT(S) OR PROJECT(S). SYMBOLS ARE NOT DRAWN TO SCALE. SIZE IS FOR CLARITY PURPOSES ONLY. SIZES AND DIMENSIONS ARE APPROXIMATE, ACTUAL MEASUREMENTS MAY VARY. DRAWINGS ARE NOT INTENDED FOR ENGINEERING OR CONSTRUCTION PURPOSES, BUT FOR ILLUSTRATIVE PURPOSES ONLY. ANY USE OF THIS DOCUMENTATION AND/OR OTHER ARTICLES PRODUCED BY RED LEONARD WITHOUT WRITTEN AUTHORIZATION FROM JAYME J. LEONARD IS STRICTLY PROHIBITED.

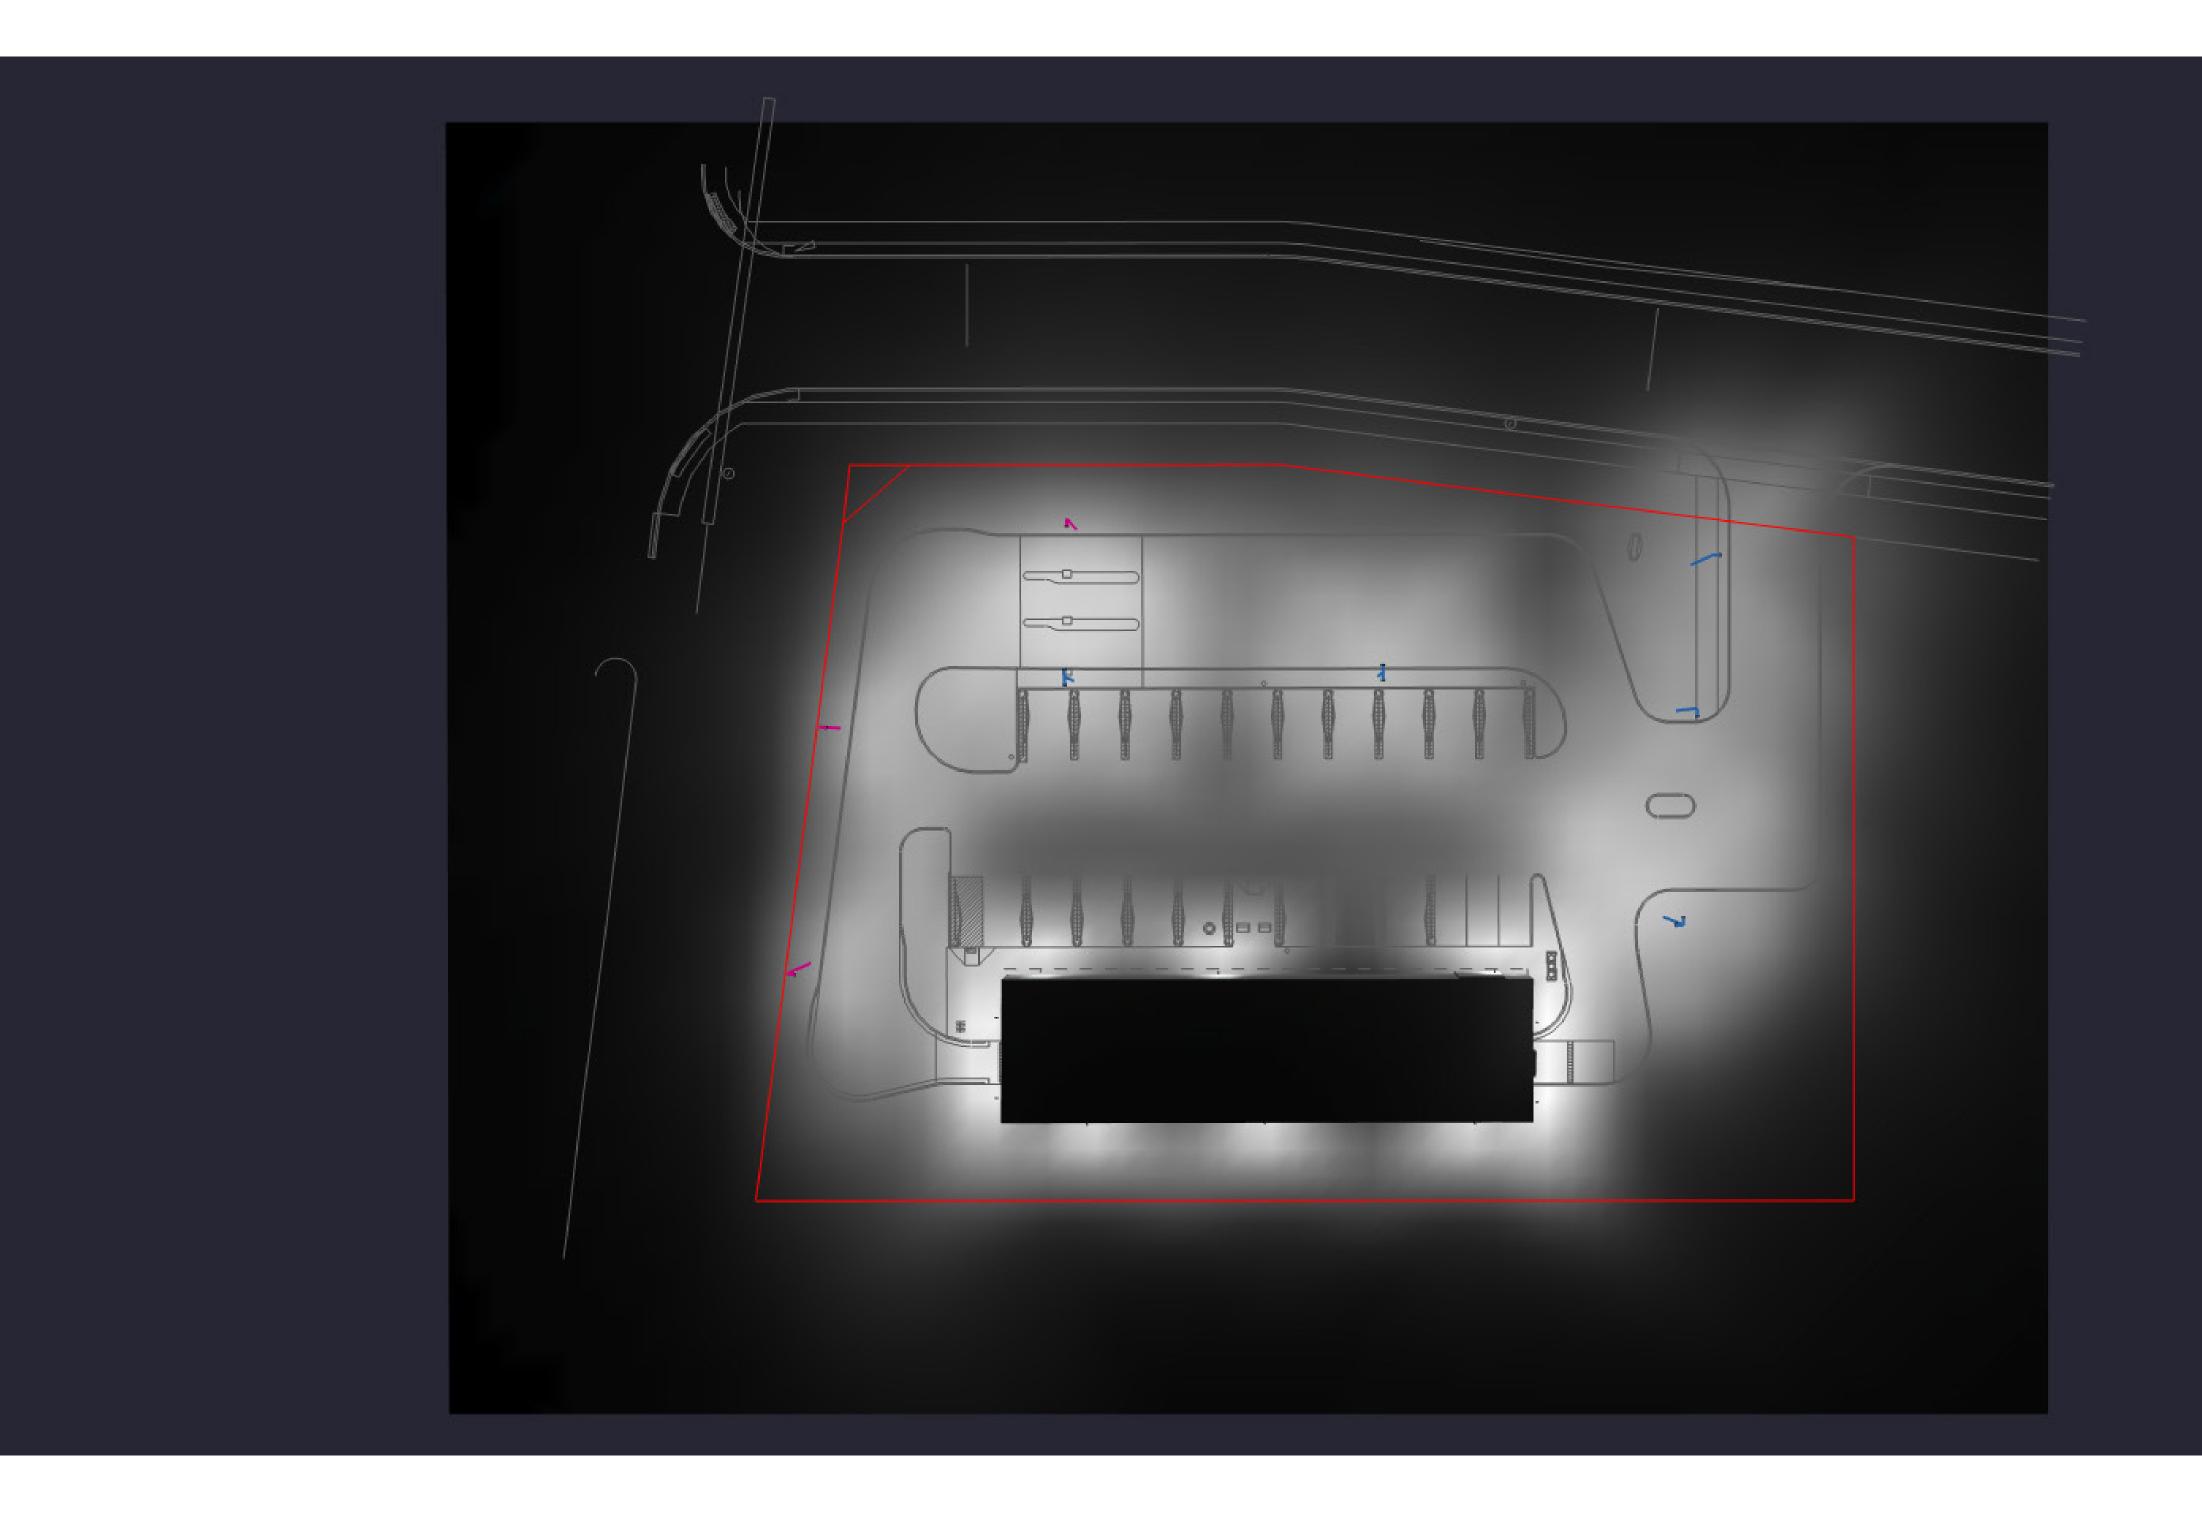




ANY SITE PLAN(S), FLOOR PLAN(S), RENDERING(S), LIGHTING LAYOUT(S) AND PHOTOMETRIC PLAN(S) INCLUDING BUT NOT LIMITED TO ANY PROJECT(S) CREATED/PRODUCED BY RED LEONARD ASSOCIATES INC., ARE ONLY INTENDED FOR ILLUSTRATION AND QUOTING PURPOSES ONLY. RED LEONARD ASSOCIATES HAS THE RIGHT TO USE THIRD PARTY LASERS, SCANNERS, AND CAMERAS BUT ACTUAL PROJECT CONDITIONS, DIMENSIONS, AND ACCURACY OF MEASUREMENTS MAY DIFFER FROM THESE OR ANY PARAMETERS. RED LEONARD ASSOCIATES INC. ASSUMES NO LIABILITY FOR WHAT IS CREATED/PRODUCED IN THESE RECREATIONS. THIS INCLUDES BUT IS NOT LIMITED TO THE USE OF, INSTALLATION OF AND/OR INTEGRITY OF EXISTING BUILDING(S), SURROUNDING AREA FOR PRODUCT(S) SUCH AS EXISTING POLE(S), ANCHOR BOLT(S), BASE(S), ARCHITECTURAL AND SIGNAGE STRUCTURE(S), LANDSCAPING PLAN(S), LIGHTING PLAN(S), FIXTURE SELECTION(S) AND PLACEMENT, MATERIAL(S), COLOR ACCURACY, TEXTURE(S), AND ANYTHING ATTRIBUTED TO PHOTO REALISM THAT IS CREATED. FURTHERMORE, RED LEONARD ASSOCIATES INC., DOES NOT ASSUME LIABILITY WHATSOEVER FOR ANY PURCHASES MADE BY CLIENT BEFORE, DURING, OR AT THE CONCLUSION OF THE PUBLISHED WORK. THE CUSTOMER, ITS RELATIVE AFFILIATES, AS WELL AS ANY OTHER PERSON(S) IN VIEWING OF THIS PRODUCT IS RESPONSIBLE FOR VERIFYING COMPLIANCE WITH ANY BUT NOT LIMITED TO ALL CODES, PERMITS, RESTRICTIONS, INSTRUCTIONS, PURCHASES, AND INSTALLATIONS OF OBJECTS VIEWED WITHIN THIS DOCUMENT(S) OR PROJECT(S). SYMBOLS ARE NOT DRAWN TO SCALE. SIZE IS FOR CLARITY PURPOSES ONLY. SIZES AND DIMENSIONS ARE APPROXIMATE, ACTUAL MEASUREMENTS MAY VARY. DRAWINGS ARE NOT INTENDED FOR ENGINEERING OR CONSTRUCTION USE. THIS DOCUMENT, ANY RED LEONARD DRAWING(S), OR PROJECT(S) IS NOT TO BE USED AND/OR INTENDED FOR ENGINEERING OR CONSTRUCTION PURPOSES, BUT FOR ILLUSTRATIVE PURPOSES ONLY. ANY USE OF THIS DOCUMENTATION AND/OR OTHER ARTICLES PRODUCED BY RED LEONARD WITHOUT WRITTEN AUTHORIZATION FROM JAYME J. LEONARD IS STRICTLY PROHIBITED.

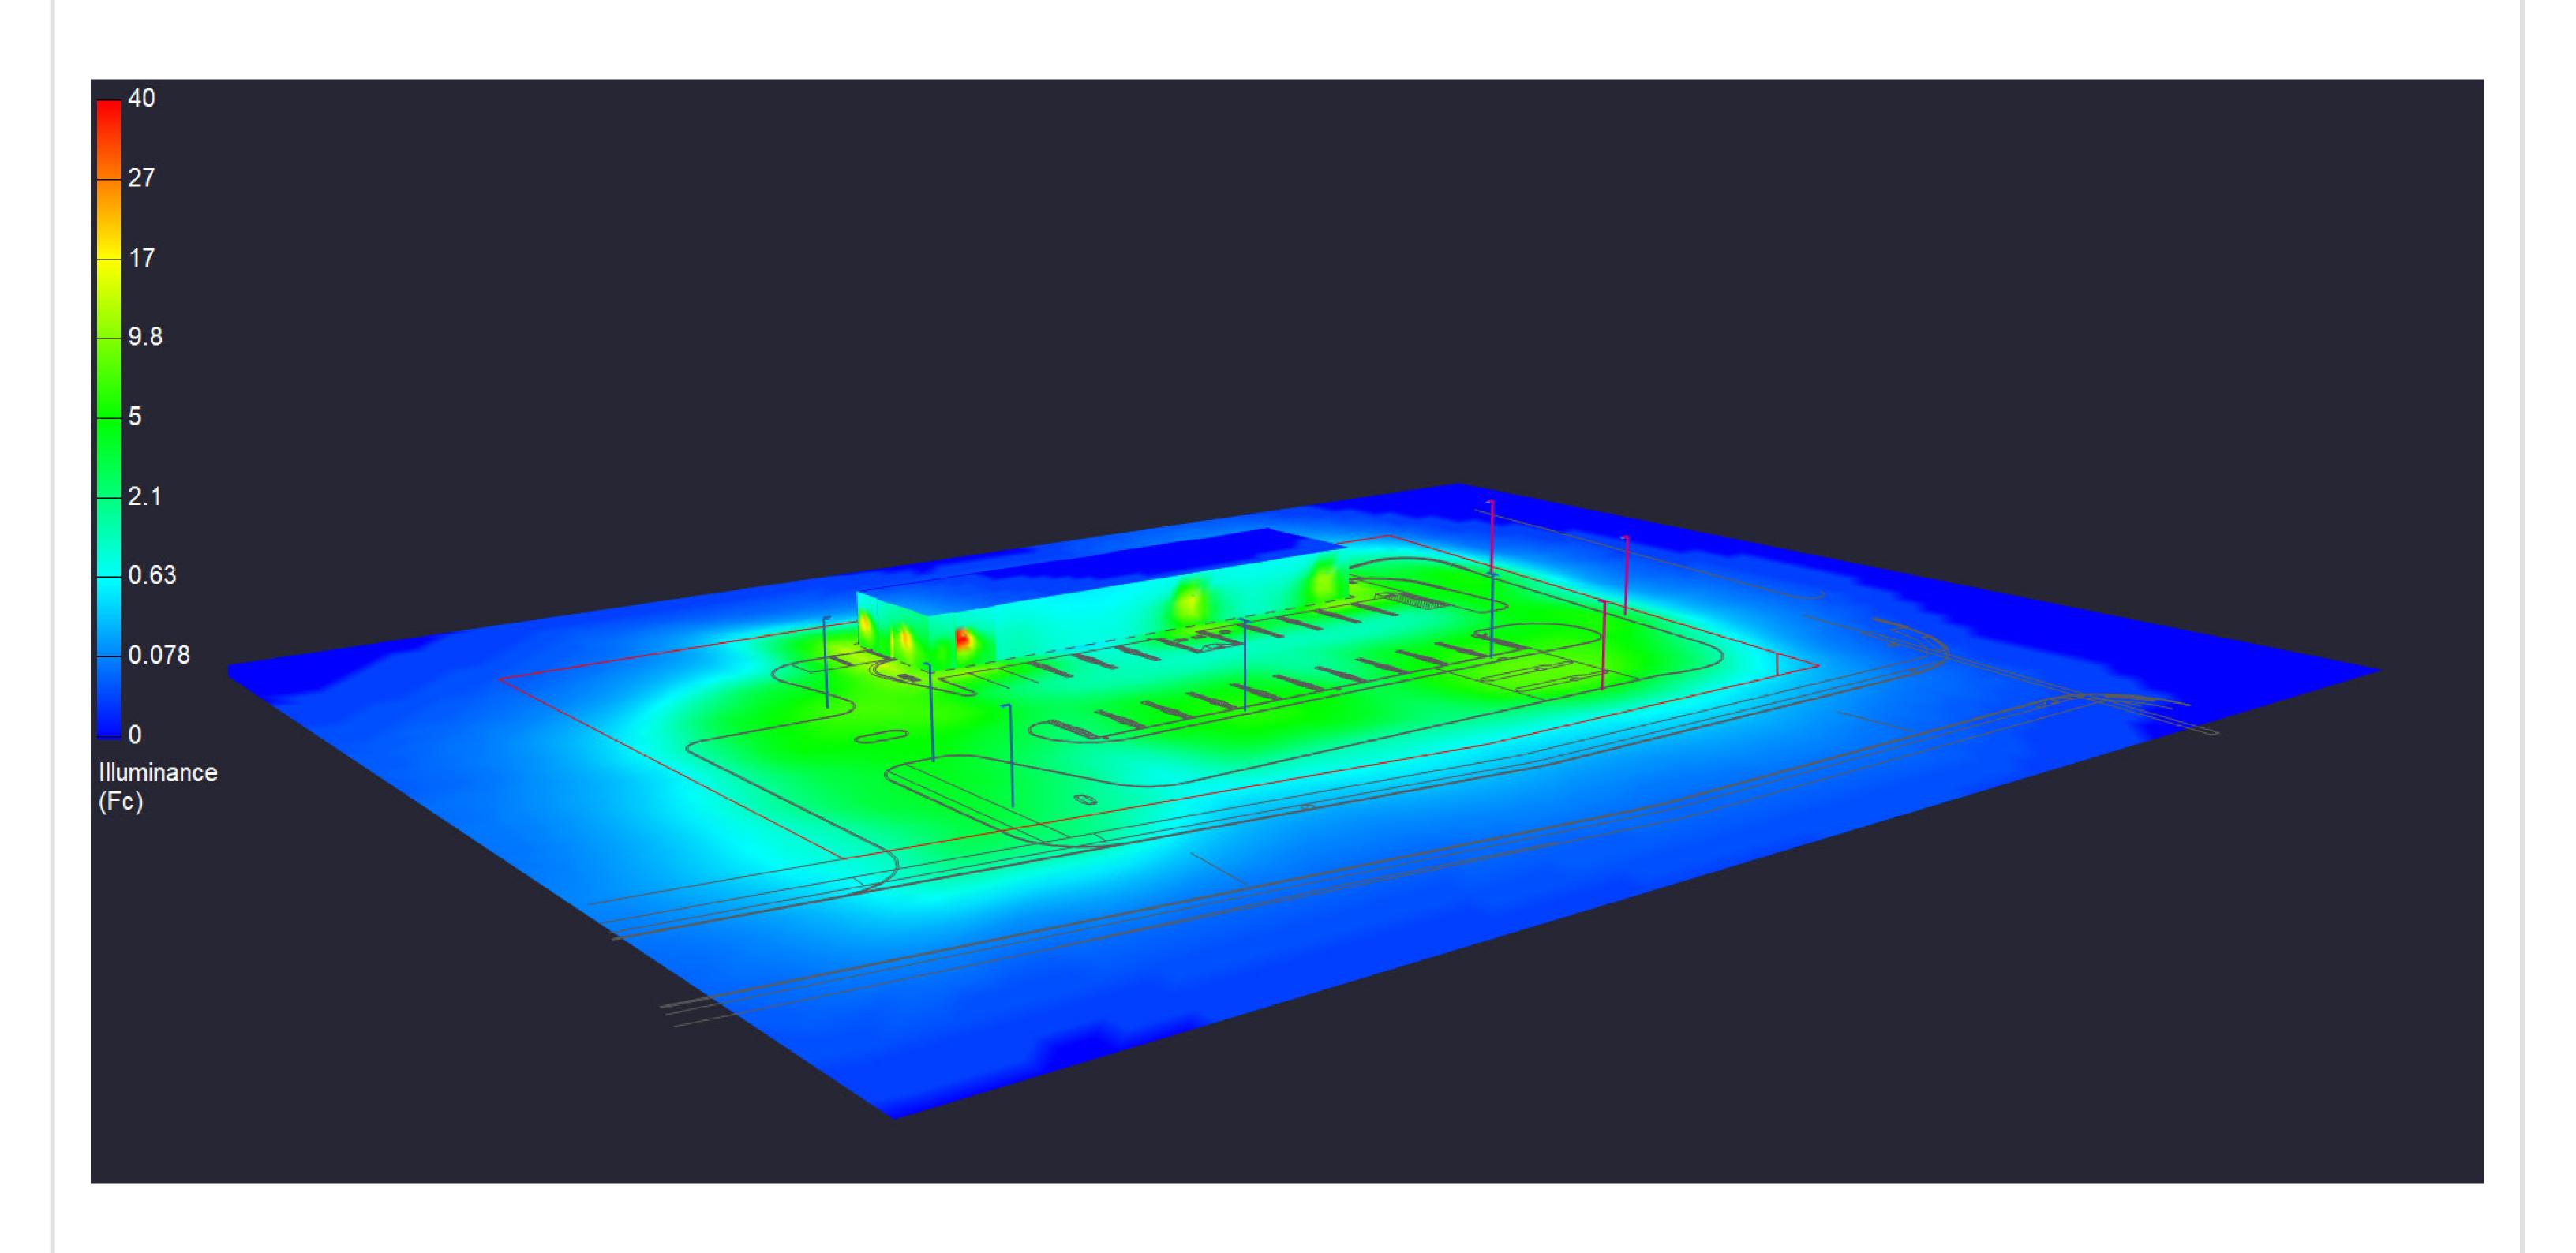



ANY SITE PLAN(S), FLOOR PLAN(S), RENDERING(S), LIGHTING LAYOUT(S) AND PHOTOMETRIC PLAN(S) INCLUDING BUT NOT LIMITED TO ANY PROJECT(S) CREATED/PRODUCED BY RED LEONARD ASSOCIATES INC., ARE ONLY INTENDED FOR ILLUSTRATION AND QUOTING PURPOSES ONLY. RED LEONARD ASSOCIATES HAS THE RIGHT TO USE THIRD PARTY LASERS, SCANNERS, AND CAMERAS BUT ACTUAL PROJECT CONDITIONS, DIMENSIONS, AND ACCURACY OF MEASUREMENTS MAY DIFFER FROM THESE OR ANY PARAMETERS. RED LEONARD ASSOCIATES INC. ASSUMES NO LIABILITY FOR WHAT IS CREATED/PRODUCED IN THESE RECREATIONS. THIS INCLUDES BUT IS NOT LIMITED TO THE USE OF, INSTALLATION OF AND/OR INTEGRITY OF EXISTING BUILDING(S), SURROUNDING AREA FOR PRODUCT(S) SUCH AS EXISTING POLE(S), ANCHOR BOLT(S), BASE(S), ARCHITECTURAL AND SIGNAGE STRUCTURE(S), LANDSCAPING PLAN(S), LIGHTING PLAN(S), FIXTURE SELECTION(S) AND PLACEMENT, MATERIAL(S), COLOR ACCURACY, TEXTURE(S), AND ANYTHING ATTRIBUTED TO PHOTO REALISM THAT IS CREATED. FURTHERMORE, RED LEONARD ASSOCIATES INC., DOES NOT ASSUME LIABILITY WHATSOEVER FOR ANY PURCHASES MADE BY CLIENT BEFORE, DURING, OR AT THE CONCLUSION OF THE PUBLISHED WORK. THE CUSTOMER, ITS RELATIVE AFFILIATES, AS WELL AS ANY OTHER PERSON(S) IN VIEWING OF THIS PRODUCT IS RESPONSIBLE FOR VERIFYING COMPLIANCE WITH ANY BUT NOT LIMITED TO ALL CODES, PERMITS, RESTRICTIONS, INSTRUCTIONS, PURCHASES, AND INSTALLATIONS OF OBJECTS VIEWED WITHIN THIS DOCUMENT(S) OR PROJECT(S). SYMBOLS ARE NOT DRAWN TO SCALE. SIZE IS FOR CLARITY PURPOSES ONLY. SIZES AND DIMENSIONS ARE APPROXIMATE, ACTUAL MEASUREMENTS MAY VARY. DRAWINGS ARE NOT INTENDED FOR ENGINEERING OR CONSTRUCTION PURPOSES, BUT FOR ILLUSTRATIVE PURPOSES ONLY. ANY USE OF THIS DOCUMENTATION AND/OR OTHER ARTICLES PRODUCED BY RED LEONARD WITHOUT WRITTEN AUTHORIZATION FROM JAYME J. LEONARD IS STRICTLY PROHIBITED.

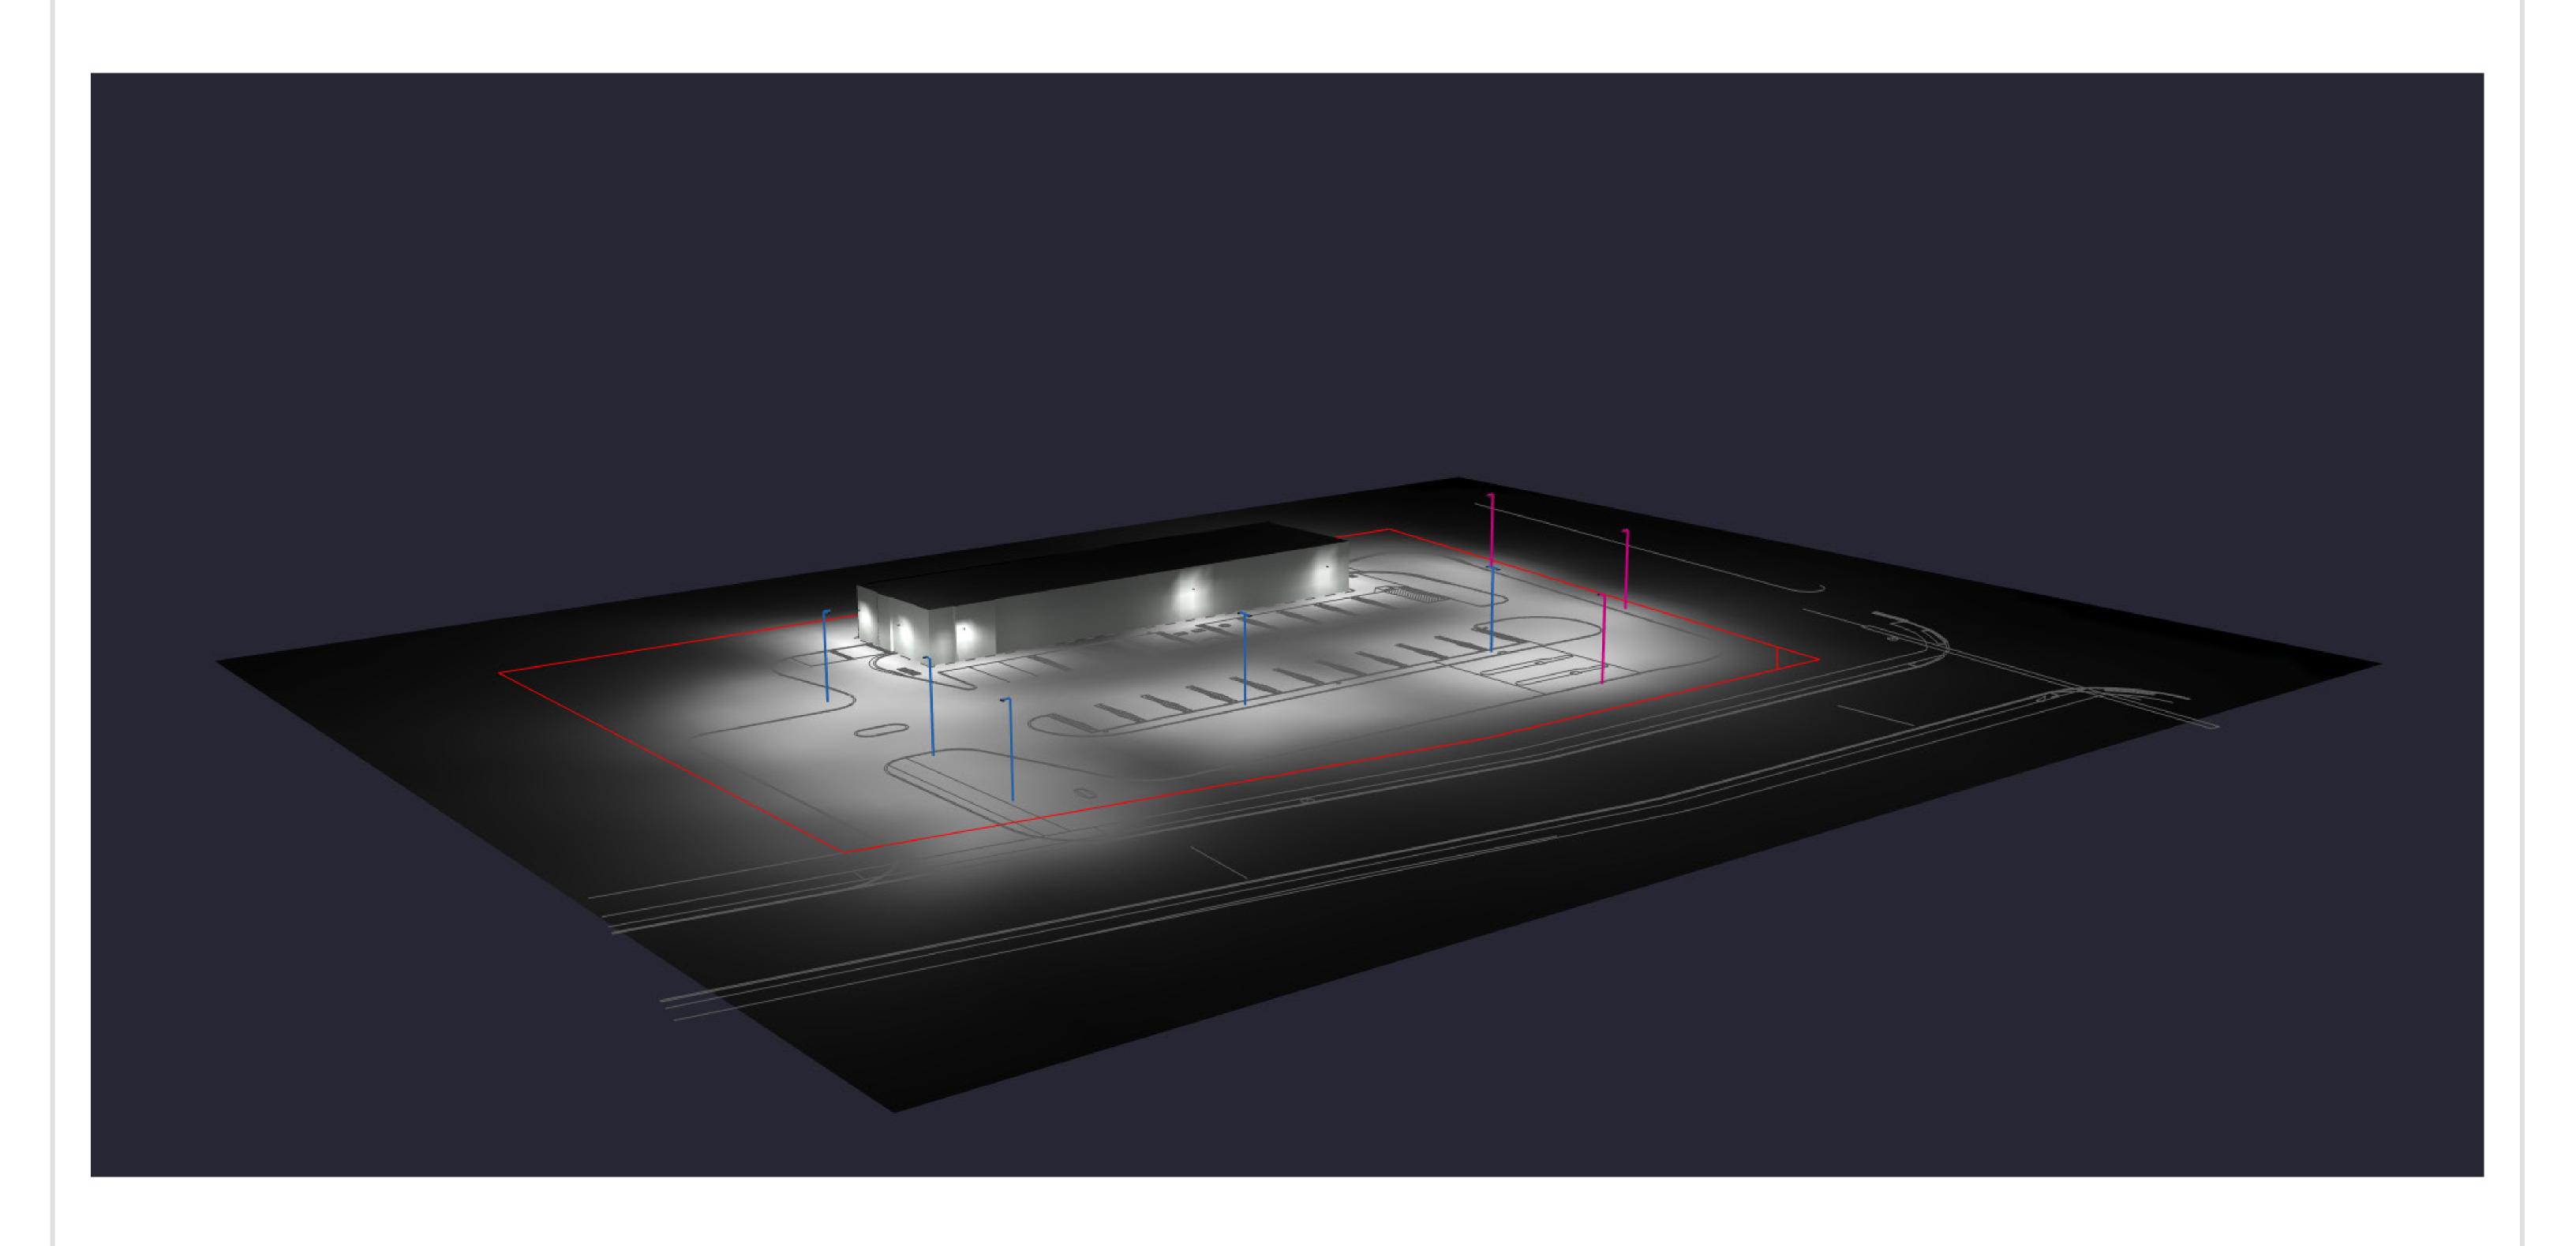



ANY SITE PLAN(S), FLOOR PLAN(S), RENDERING(S), LIGHTING LAYOUT(S) AND PHOTOMETRIC PLAN(S) INCLUDING BUT NOT LIMITED TO ANY PROJECT(S) CREATED/PRODUCED BY RED LEONARD ASSOCIATES INC., ARE ONLY INTENDED FOR ILLUSTRATION AND QUOTING PURPOSES ONLY. RED LEONARD ASSOCIATES HAS THE RIGHT TO USE THIRD PARTY LASERS, SCANNERS, AND CAMERAS BUT ACTUAL PROJECT CONDITIONS, DIMENSIONS, AND ACCURACY OF MEASUREMENTS MAY DIFFER FROM THESE OR ANY PARAMETERS. RED LEONARD ASSOCIATES INC. ASSUMES NO LIABILITY FOR WHAT IS CREATED/PRODUCED IN THESE RECREATIONS. THIS INCLUDES BUT IS NOT LIMITED TO THE USE OF, INSTALLATION OF AND/OR INTEGRITY OF EXISTING BUILDING(S), SURROUNDING AREA FOR PRODUCT(S) SUCH AS EXISTING POLE(S), ANCHOR BOLT(S), BASE(S), ARCHITECTURAL AND SIGNAGE STRUCTURE(S), LANDSCAPING PLAN(S), LIGHTING PLAN(S), FIXTURE SELECTION(S) AND PLACEMENT, MATERIAL(S), COLOR ACCURACY, TEXTURE(S), AND ANYTHING ATTRIBUTED TO PHOTO REALISM THAT IS CREATED. FURTHERMORE, RED LEONARD ASSOCIATES INC., DOES NOT ASSUME LIABILITY WHATSOEVER FOR ANY PURCHASES MADE BY CLIENT BEFORE, DURING, OR AT THE CONCLUSION OF THE PUBLISHED WORK. THE CUSTOMER, ITS RELATIVE AFFILIATES, AS WELL AS ANY OTHER PERSON(S) IN VIEWING OF THIS PRODUCT IS RESPONSIBLE FOR VERIFYING COMPLIANCE WITH ANY BUT NOT LIMITED TO ALL CODES, PERMITS, RESTRICTIONS, INSTRUCTIONS, PURCHASES, AND INSTALLATIONS OF OBJECTS VIEWED WITHIN THIS DOCUMENT(S) OR PROJECT(S). SYMBOLS ARE NOT DRAWN TO SCALE. SIZE IS FOR CLARITY PURPOSES ONLY. SIZES AND DIMENSIONS ARE APPROXIMATE, ACTUAL MEASUREMENTS MAY VARY. DRAWINGS ARE NOT INTENDED FOR ENGINEERING OR CONSTRUCTION PURPOSES, BUT FOR ILLUSTRATIVE PURPOSES ONLY. ANY USE OF THIS DOCUMENTATION AND/OR OTHER ARTICLES PRODUCED BY RED LEONARD WITHOUT WRITTEN AUTHORIZATION FROM JAYME J. LEONARD IS STRICTLY PROHIBITED.