


DRAWING INFORMATION

- ① SURFACE REFLECTANCES:
BUILDINGS: 0.5
GROUND: 0.2
- ② LUMINAIRE MOUNTING HEIGHTS
INDICATED IN DRAWINGS BY MH
WALL SCONCE - M/H INDICATED IS
DISTANCE FROM FLOOR TO CENTER OF
FIXTURE
- ③ SUSPENDED FIXTURE - M/H INDICATED
IS DISTANCE FROM FLOOR TO U/S OF
FIXTURE
- ④ CALCULATION POINT PLANE INDICATED
IN SCHEDULE

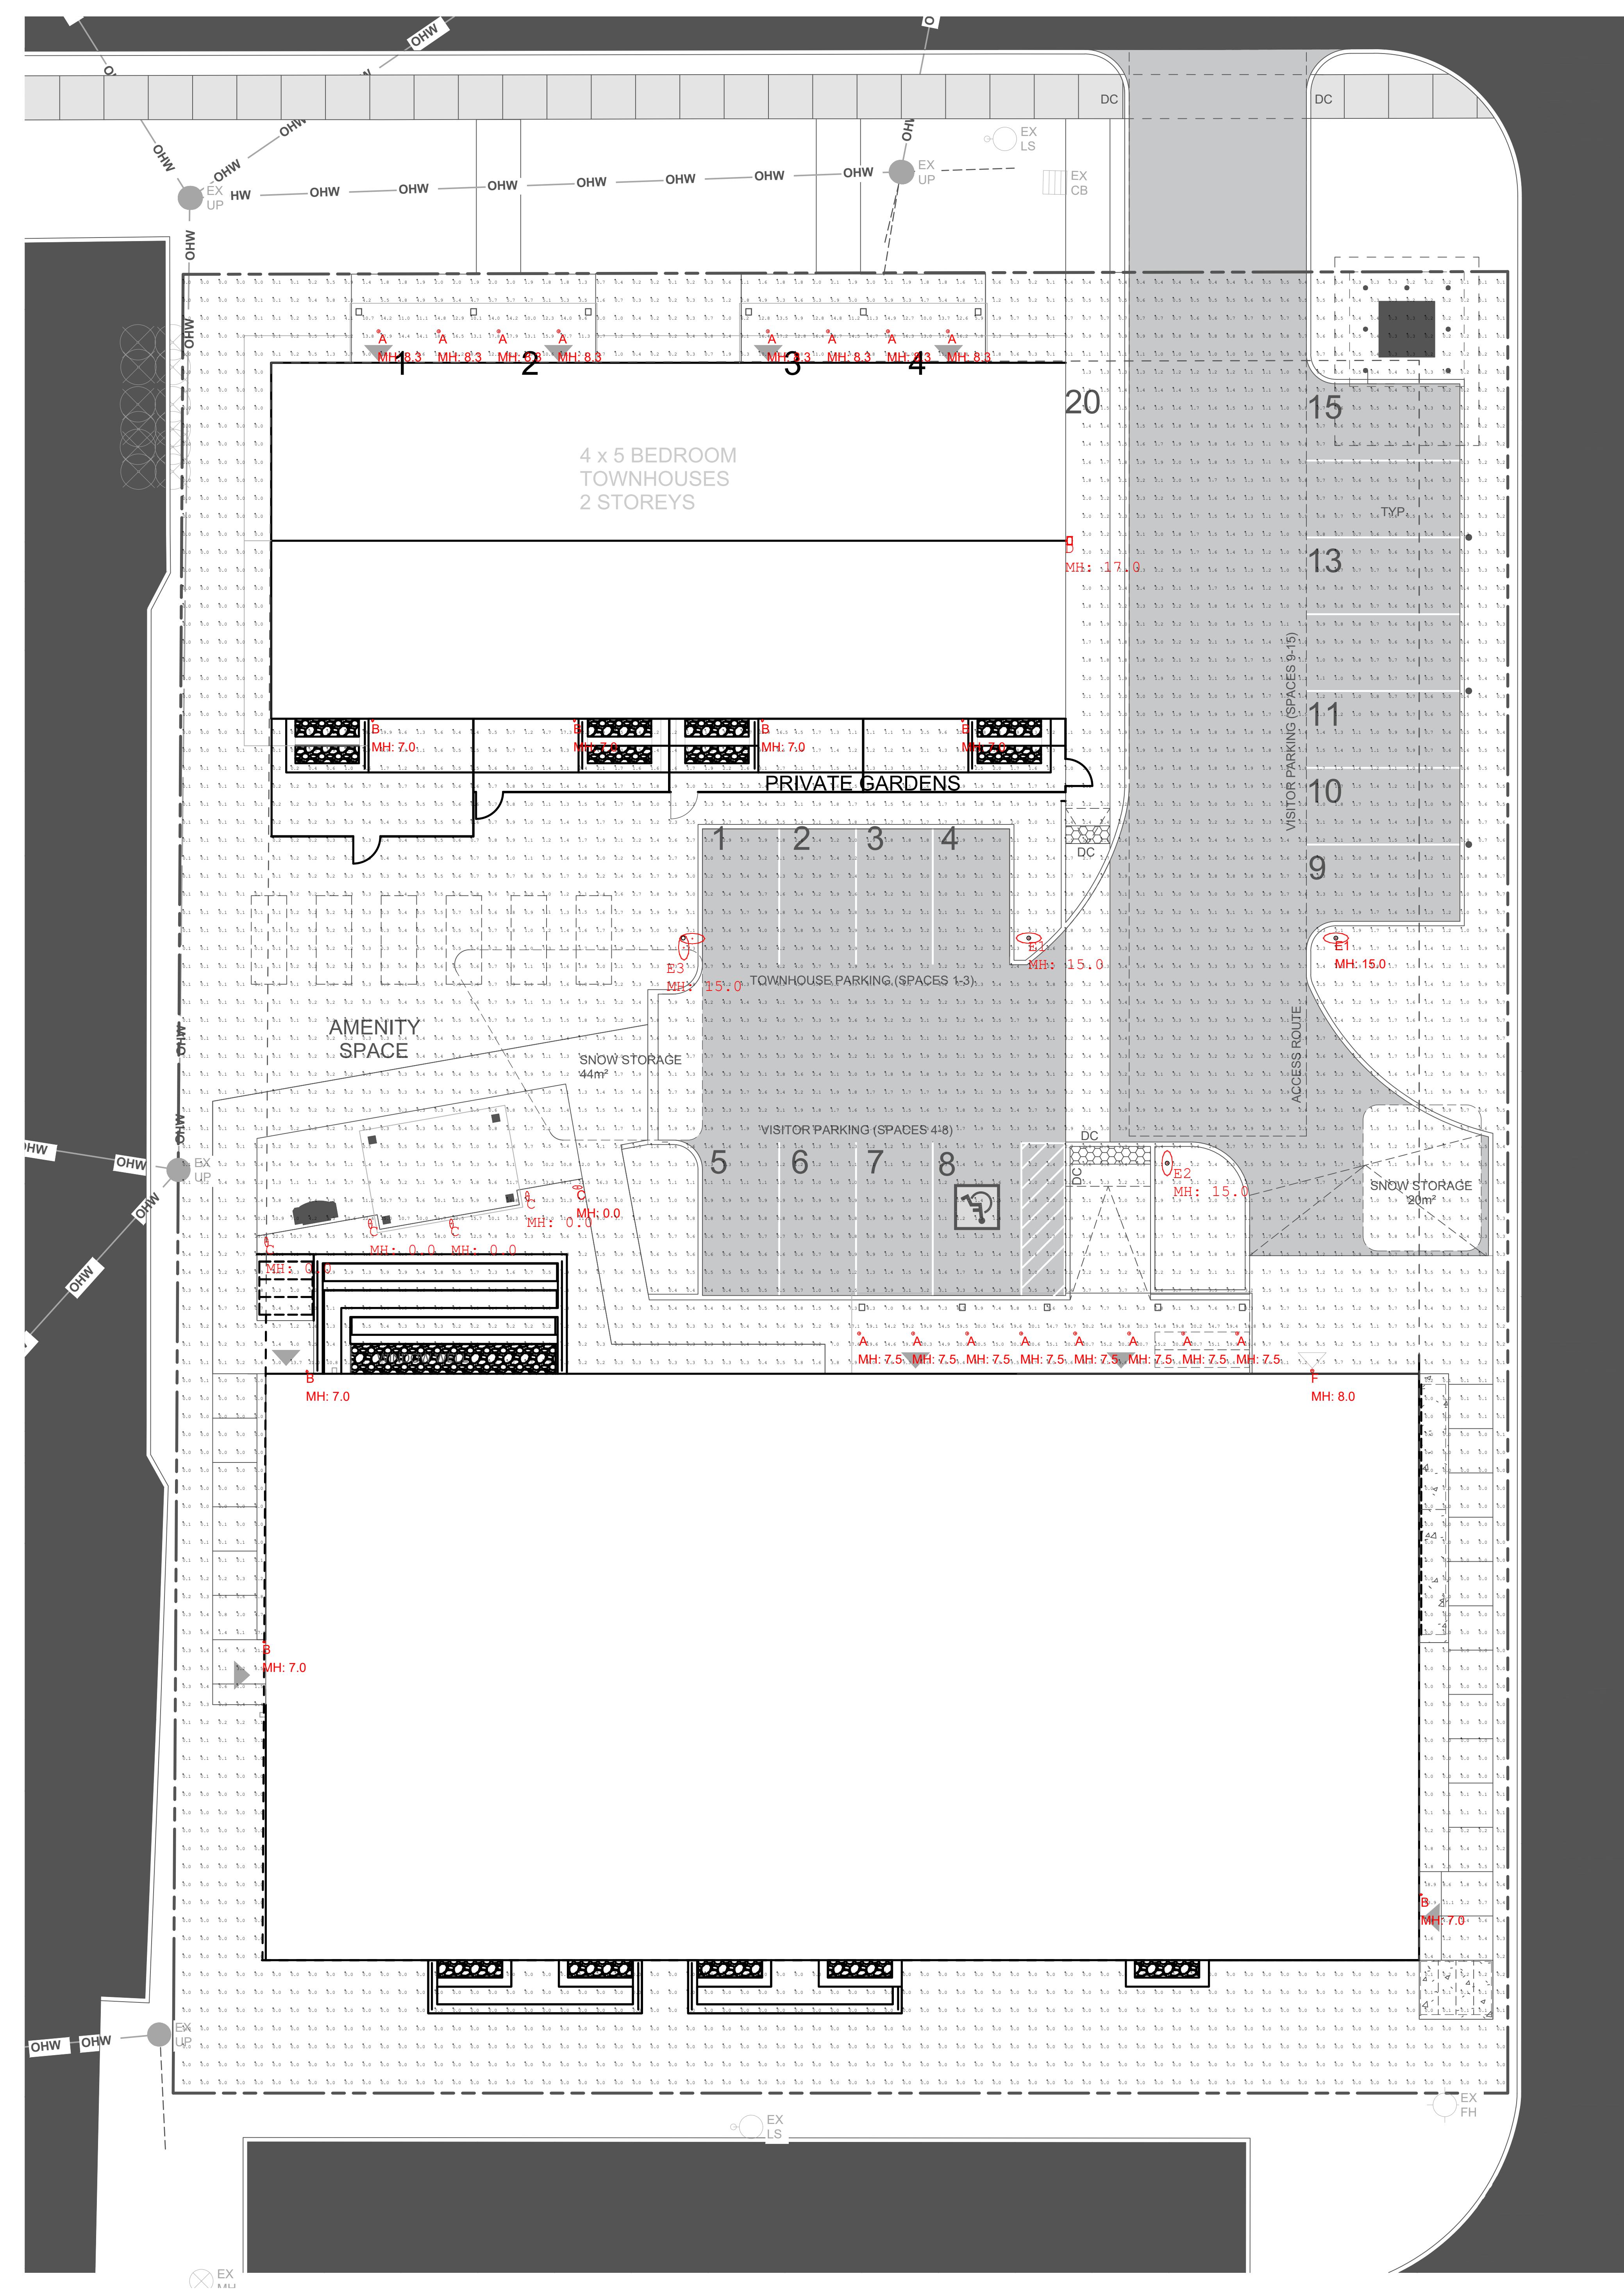

1 POINT BY POINT PHOTOMETRIC CALCULATION
L-02 SCALE: 1:100

2 SCHEDULE AND CALCULATION SUMMARY
L-02 SCALE: NTS

Calculation Summary

Label CalType Units Avg Max Min AvgMin MaxMin

SITE_Planar Illuminance Fc 1.92 25.5 0.0 N/A N/A

Luminaire Schedule

Image	Symbol	Qty	Label	Manufacturer	Description	No. Lamps	Lum. Watts	Lumens/Lamp	LLF	Notes
		16	A	LITELINE	RAS3-12F-30K-900WH	1	11.36	802	0.900	RECESSED
		7	B	TECH LIGHTING	7000WQHA00012BUJUNVS	1	11.9	N.A.	0.900	WALL
		5	C	ANP LIGHTING	BL0131A010L02T20K-XX-XX	1	15.3	N.A.	0.900	BOLLARD
		1	D	GREE	XSPW-B-WM-4ME-4L-30K-UL-XX	1	33	N.A.	0.900	WALL
		2	E1	ANP LIGHTING	SLP340300LDST430K-SGL-15-X-HSS150-1-XX	1	30	N.A.	0.900	POLE
		1	E2	ANP LIGHTING	SLP340300LDST20K-SGL-15-X-HSS150-1-XX	1	30	N.A.	0.900	POLE
		1	E3	ANP LIGHTING	SLP340300LDST430K-BTB-15-X-HSS150-1-XX + SLP340300LDST430K-BTB-14-X-HSS150-1-XX	N.A.	N.A.	N.A.	0.900	POLE
		1	F	TECH LIGHTING	700WBSROW48-LED830	1	17.9	N.A.	0.900	WALL

1 ISSUED FOR REVIEW
REV. DESCRIPTION DATE
STAMP

Project name: 56 CAPILANO
Drawing name: PHOTOMETRIC SUMMARY

Date: Drawn by: AS SHOWN
Checked by: M AL-SOLEH

2023.03.07
2023.03.07

Project number: Drawing number:
23109 L-02

Lighting • Controls • Shades

FUX
Control the Experience

2936 Baseline Road, Suite 100
Ottawa, Ontario
Tel: 613-592-9948
Fax: 613-592-9984
www.fuxlighting.ca