



EXTERIOR LIGHTING FIXTURE SCHEDULE								
TYPE	DESCRIPTION	CATALOG NUMBER	LAMPS PER FIXTURE			VOLT	MOUNTING	REMARKS
			TYPE	WATTS	COLOUR			
A	WALL SCONCE	WAC LIGHTING	LED	8.4	3000K	120	SURFACE	C/W ACCESSORIES
		WS-W27106-30						
B1	BOLLARD	SIGNIFY GARDCO	LED	10.6	3000K	120	SURFACE	C/W ACCESSORIES
		PBL-42-14L-200-WW-G2-5-UNV						
B2	BOLLARD	SIGNIFY GARDCO	LED	10.6	3000K	120	SURFACE	C/W ACCESSORIES
		PBL-42-14L-200-WW-G2-3-UNV						
C	WALL MOUNTED	WAC LIGHTING	LED	16.7	3000K	120	SURFACE	C/W ACCESSORIES
		DC-WE0517-F30A						
P	POLE	GARDCO	LED	50.4	3000K	120	SURFACE	C/W ACCESSORIES
		PPT-C-A04-830-T5M						
R	RECESSED	BEGA	LED	22	3000K	120	SURFACE	C/W ACCESSORIES
		24806K3						
S	RECESSED	BEGA	LED	11	3000K	120	SURFACE	C/W ACCESSORIES
		33055K3						
W	WALL SCONCE	SIGNIFY GARDCO	LED	28.1	3000K	120	SURFACE	C/W ACCESSORIES
		101L-16L-530-WW-G2-4						

NOTE: LIGHT FIXTURES EQUAL IN AESTHETICS AND PERFORMANCE ARE ACCEPTABLE.
ALL LED FIXTURES SHALL BE C/W DRIVERS.

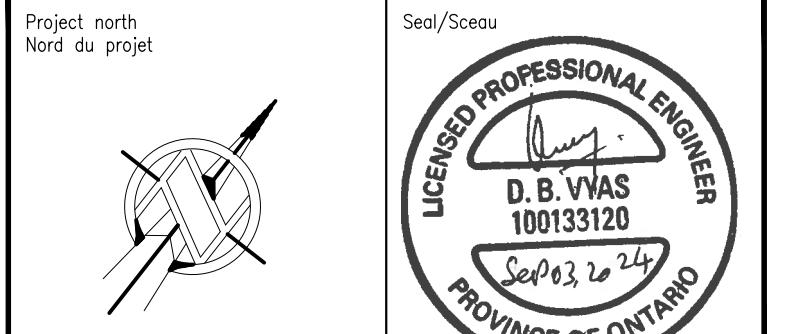

Scale Échelle	AS NOTED	Project no./No. du projet 2024-220
Design by Conçu par	L. ALI	Drawing/Dessin
Drawn by Dessiné par	H. PANDEY	E02A
Reviewed by Examiné par	D. VYAS	OF
Date Date	SEPTEMBER 2024	Revision no: —
		Acad file/Fichier: —

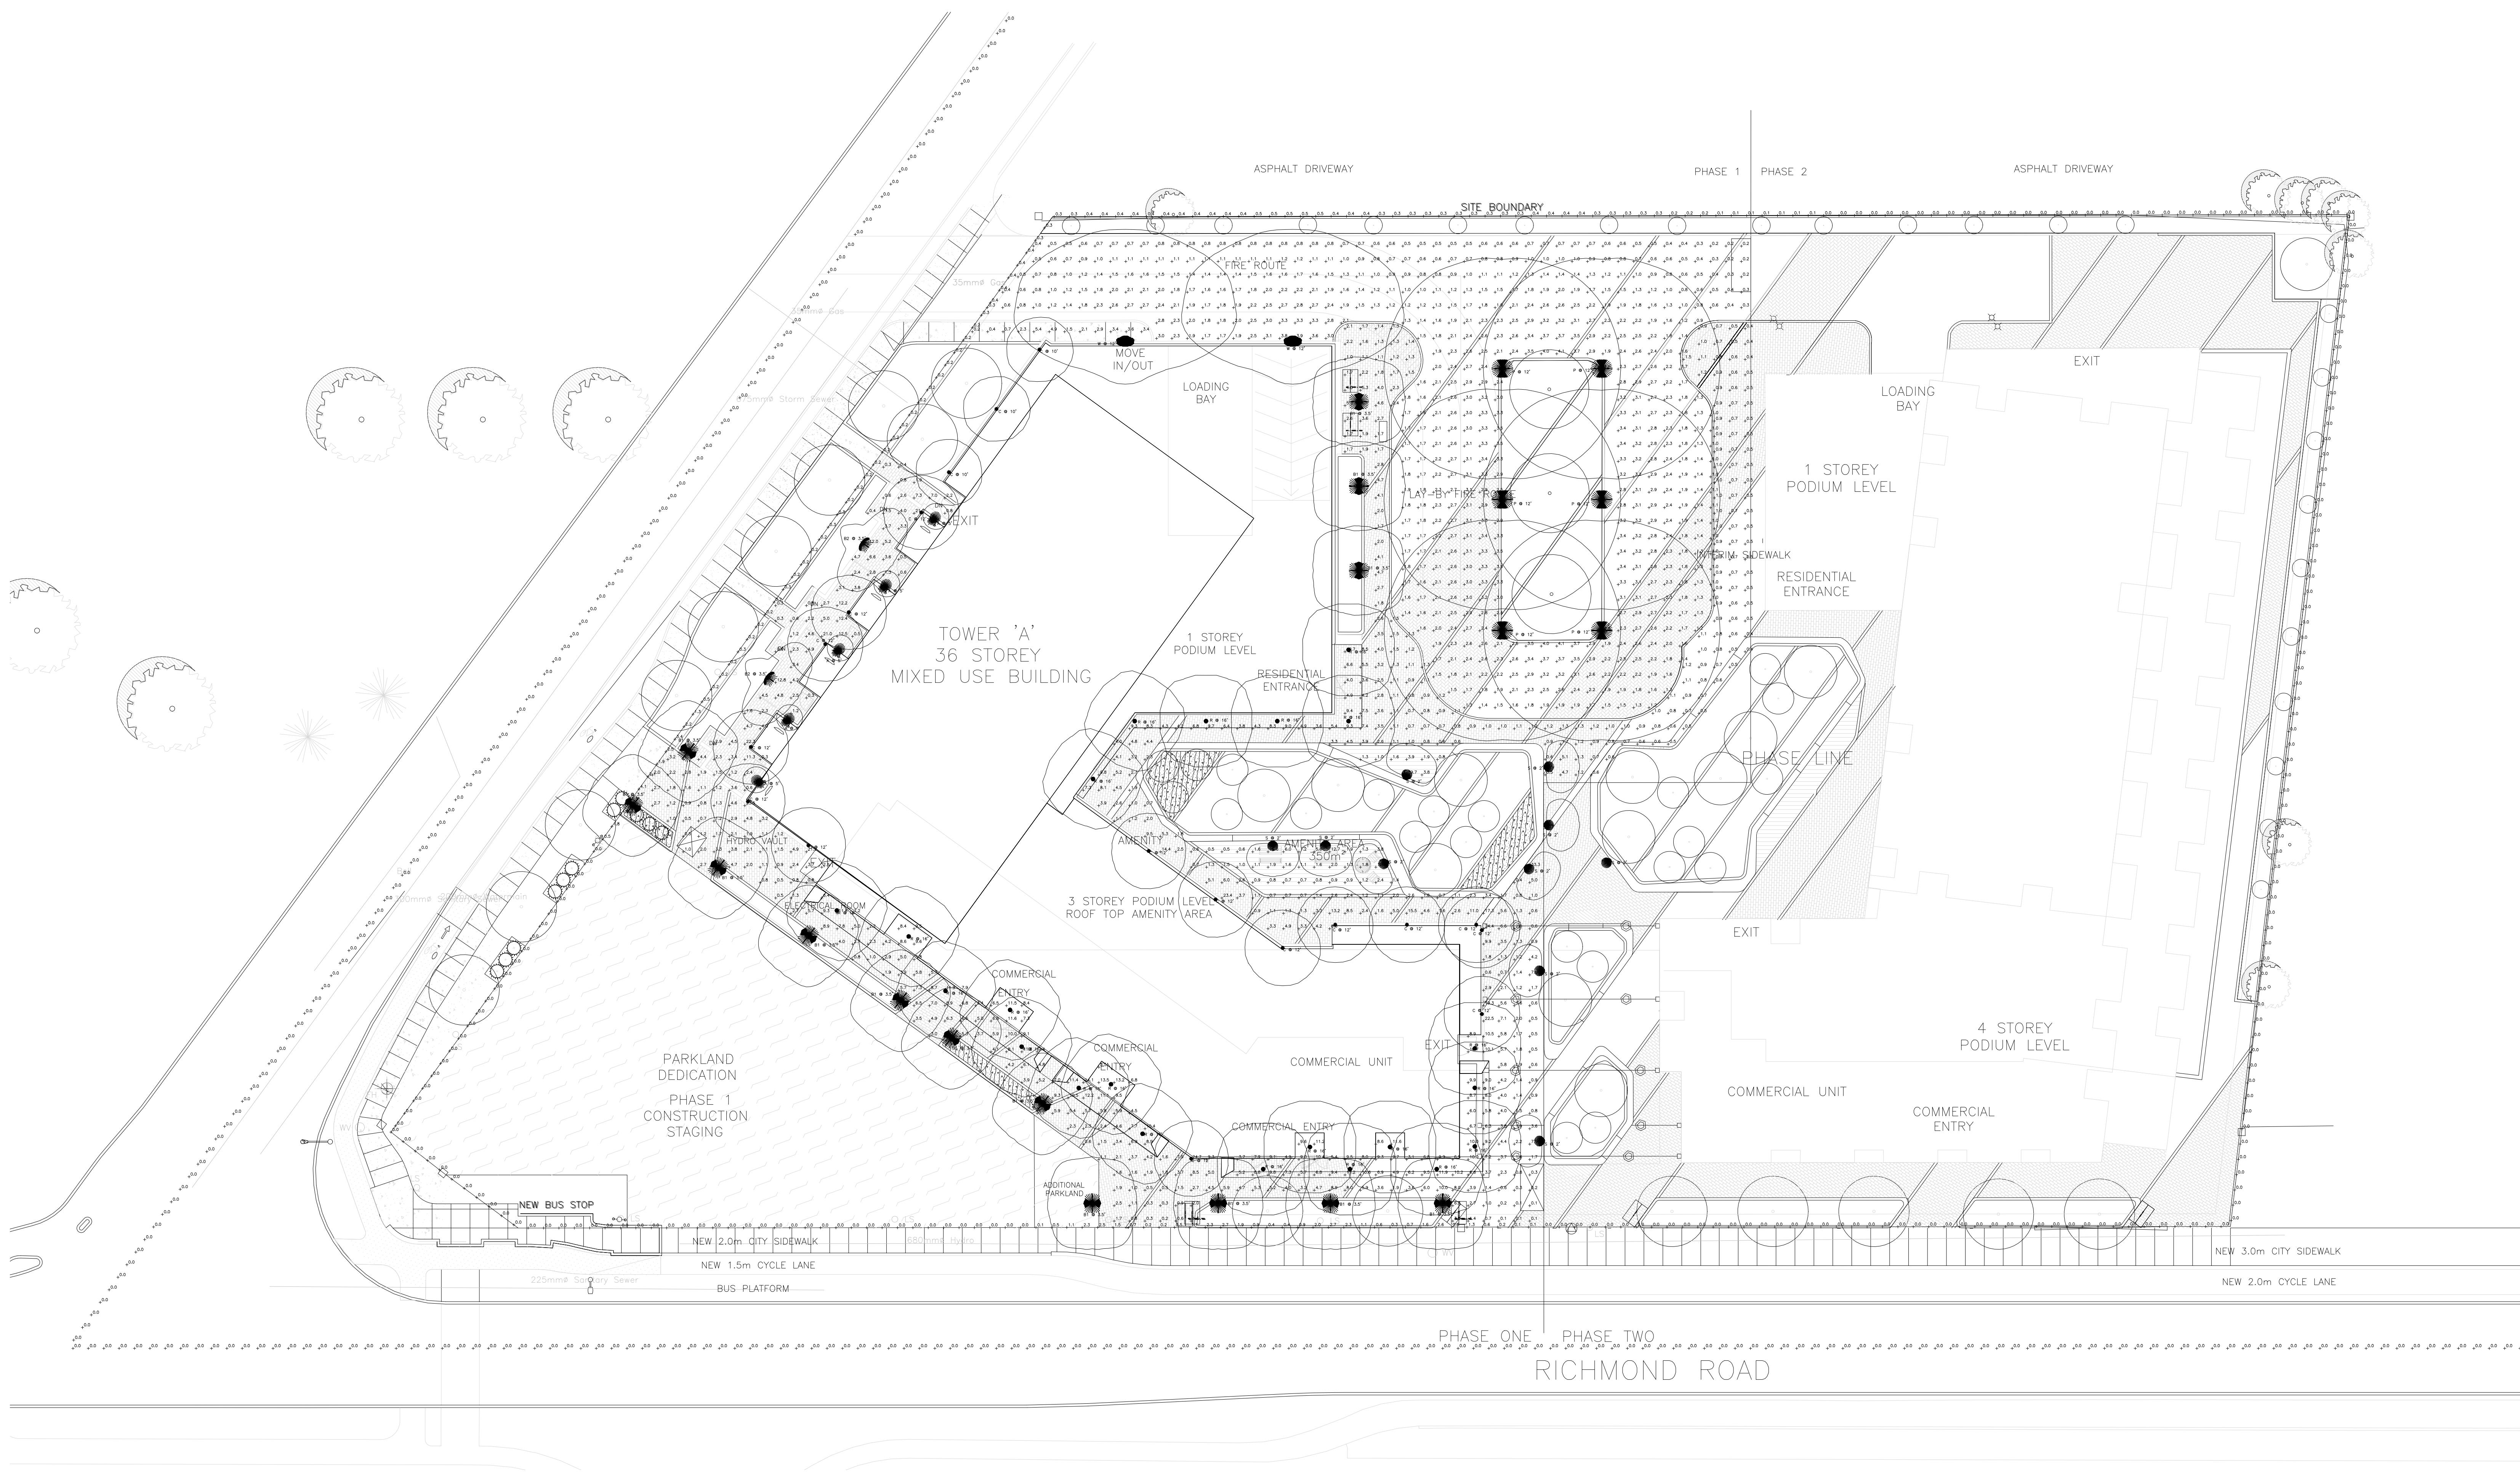

1 SITE LIGHTING PHOTOMETRIC LAYOUT
E02B 1:200

Statistics						
Description	Symbol	Avg	Max	Min	Max/Min	Avg/Min
North West Sidewalk	+	2.6 fc	5.4 fc	0.2 fc	27.0:1	13.0:1
Property Line	+	0.3 fc	5.3 fc	0.0 fc	N/A	N/A
Property Line - Middle of Road	+	0.0 fc	0.0 fc	0.0 fc	N/A	N/A
Walkways	+	3.8 fc	39.7 fc	0.1 fc	397.0:1	38.0:1
Driveway	+	1.9 fc	4.1 fc	0.2 fc	20.5:1	9.5:1

THE ENGINEER WAIVES ANY AND ALL RESPONSIBILITY AND LIABILITY FOR PROBLEMS WHICH ARISE FROM FAILURE TO FOLLOW THESE PLANS, SPECIFICATIONS AND THE DESIGNERS' GUIDANCE. THE ENGINEER IS NOT RESPONSIBLE FOR PROBLEMS WHICH RESULT FROM FAILURE TO OBTAIN AND / OR FOLLOW THE ENGINEER'S GUIDANCE WITH RESPECT TO ANY ERRORS, OMISSIONS, INCONSISTENCIES, AMBIGUITIES OR CONFLICTS WHICH ARE ALLEGED. THIS DRAWING IS THE PROPERTY OF GOODKEY WEEDMARK & ASSOCIATES LIMITED AND NO PART OF IT MAY BE COPIED OR USED WITHOUT THE EXPRESS WRITTEN CONSENT OF THE OWNER. THE USE OF THIS DRAWING MAY BE MADE WITHOUT EXPRESS WRITTEN CONSENT.


DO NOT SCALE DRAWINGS

L'INGÉNIEUR DÉCLINE TOUTE RESPONSABILITÉ RELATIVEMENT À DES PROBLÈMES FAISANT SURVIVRE DE LA FAUTE DE CEUX PLANS, RÈGLES ET D'INSTRUCTIONS DU CONSEIL QUISSONT INDUITS OU DE TOUS LES PROBLÈMES POUVANT RÉSULTER DU DÉFAUT D'OBÉIR À TOUTES LES INSTRUCTIONS DE L'INGÉNIEUR EN CE QUI CONCERNÉ LES ERREURS, OMISSES, INCONSISTANCES, AMBIGUITÉS OU CONFLITS ALLEGÉS.

CE DOCUMENT EST LA PROPRIÉTÉ LITTÉRALE DE GOODKEY WEEDMARK & ASSOCIATES LIMITED ET TOUS LES DROITS SONT RÉSERVÉS. L'UTILISATION EST INTITRÉE, SAUF LE CONSENTEMENT EXPRES DE L'AUTEUR.
NE PAS MESURER LES DÉSSINS À L'ÉCHELLE.

Goodkey Weedmark
Consulting Engineers

GOODKEY WEEDMARK & ASSOCIATES LIMITED
1688 Woodward Dr.
Ottawa Ontario
Canada K2C 3R8
613 727-5111
613 727-5115
Fax
www.gwal.com
Web

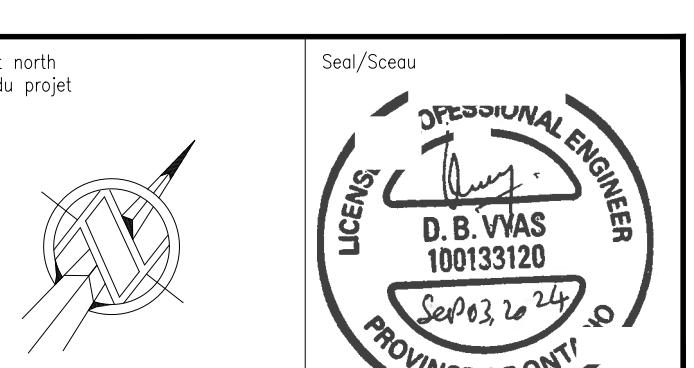

Project/Project
1047 RICHMOND ROAD

Drawing title/Titre du dessin
SITE LIGHTING
PHOTOMETRIC LAYOUT

Scale AS NOTED
Echelle AS NOTÉ
Design by L. ALI
Conçu par
Drawn by H. PANDEY
Dessiné par
Reviewed by D. VYAS
Examined by
Date SEPTEMBER 2024
Date

Project no./No. du projet
2024-220
Drawing/Dessin
E02B
of 01
Revision no.:
Acad file/Fichier:
—