


# CITY PARK REDEVELOPMENT PHASE 2

2280 CITY PARK DRIVE, OTTAWA - ONTARIO

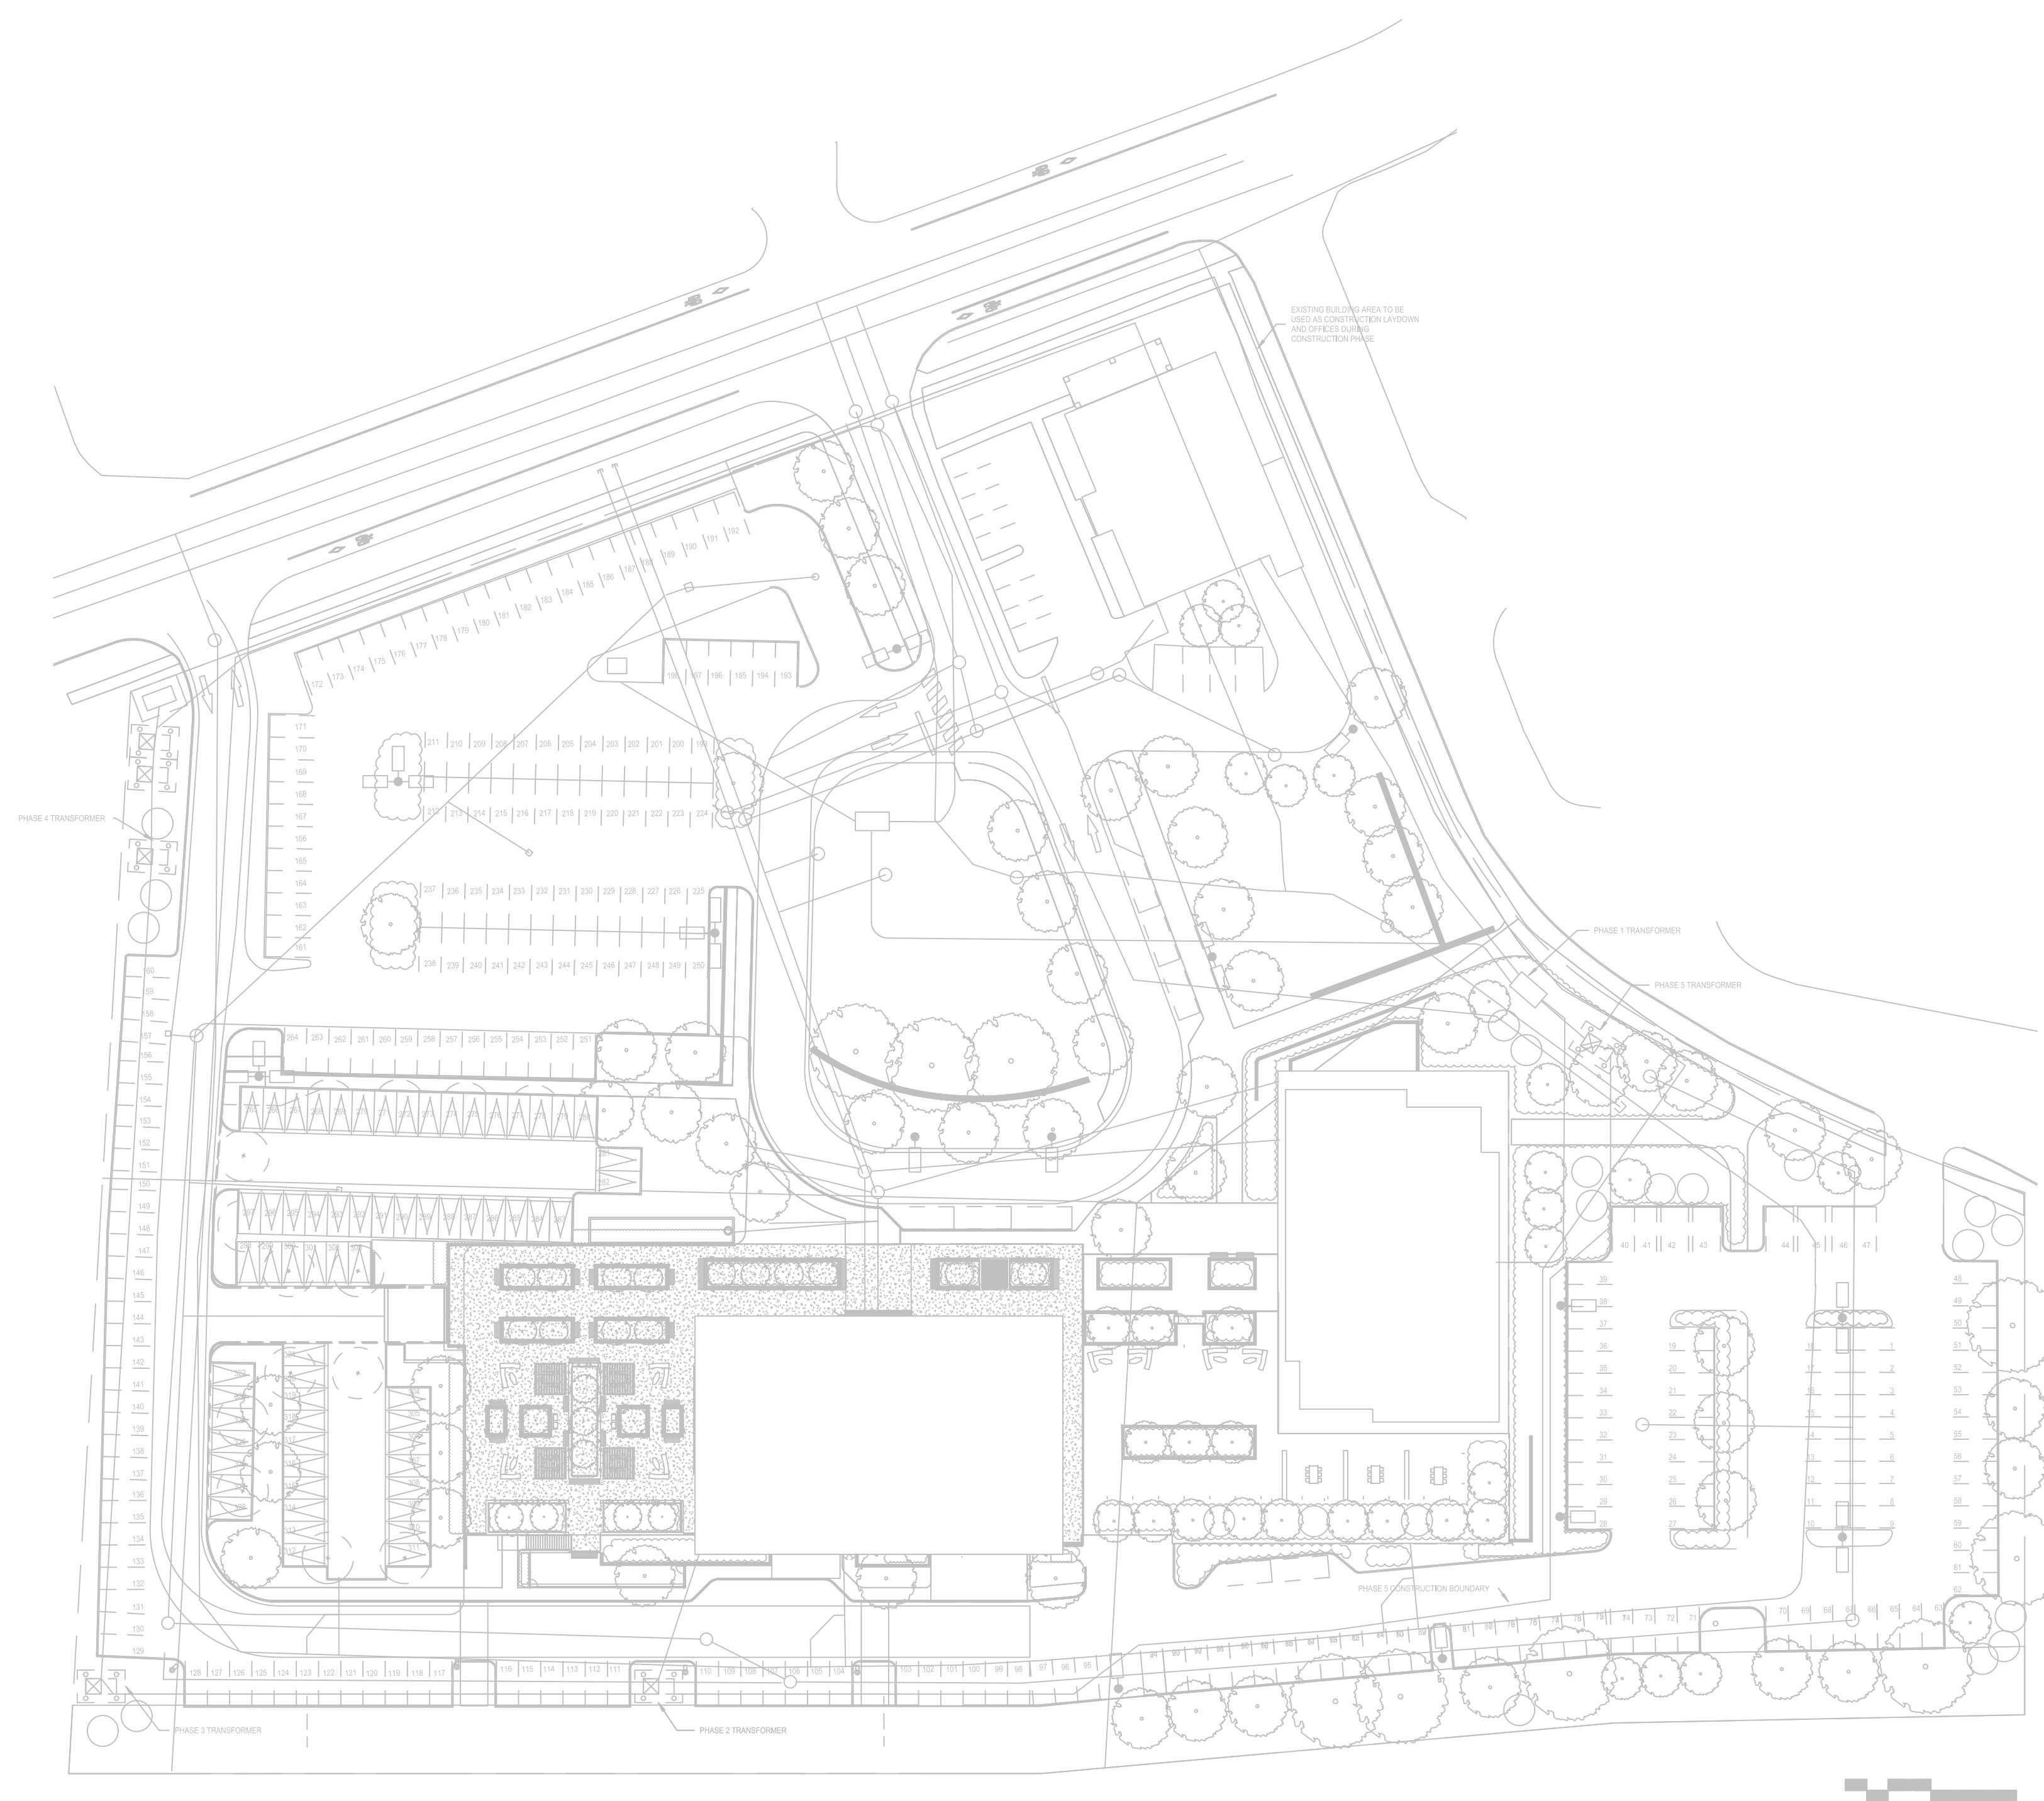

ELECTRICAL DRAWING LIST	
DRAWING NUMBER	DESCRIPTION
E000	ELECTRICAL DRAWING LIST
E100	ELECTRICAL SITE PLAN

1 08/21/25 ISSUED FOR SPRA  
0 07/31/25 ISSUED FOR 75% CD  
no. date revision

It is the responsibility of the appropriate contractor to verify all dimensions on site and report all errors and/or omissions to the engineer.

All contractors must comply with all

Do not scale drawings.

This drawing may not be used for construction until signed.

Copyright reserved.

Hobin Architecture Incorporated  
63 Parilia Street  
Ottawa, Ontario  
Canada K1S 3K7  
T: 613-238-7200  
F: 613-238-2005  
E: mail@hobinarc.com  
hobinarc.com



PROJECT: RIOCAN - CITY PARK PHASE 2  
200 FRONTIER PATH PRIVATE  
DRAWING TITLE: ELECTRICAL DRAWING LIST

DRAWN: DATE: 07/31/25 SCALE: NO SCALE  
PROJECT: 16652.004  
NORTH ARROW: DRAWING NO.: 16652.004  
LICENCED PROFESSIONAL ENGINEER: DRAWING NO.: 16652.004  
PROVINCE OF ONTARIO: DRAWING NO.: 16652.004  
2025-08-28 20496752  
16652.004  
16652.004

VERSION NO.: E000

